



Founded 1957 ♦ Pearson, Humphries, & Jones Architects

Renis Jones III, AIA | Patrick T. Addison, AIA | Brian J. Klinkhammer, AIA | Steven R. Hall, AIA

ADDENDUM NO. 1

DATED: SEPTEMBER 15, 2026

PROJECT: **REBID**
New Fleet Management Building for AIDT
Montgomery, Alabama

PH&J No: 2502-CUA



1A-1 GENERAL

THIS AMENDMENT IS HEREBY MADE PART OF THE BID/CONTRACT DOCUMENTS AND AS SUCH MUST BE ACKNOWLEDGED WITH THE BID. FAILURE TO DO SO MAY SUBJECT THE BIDDER TO DISQUALIFICATION. THE FOLLOWING CONDITIONS TAKE PRECEDENCE OVER CONFLICTING CONDITIONS IN THE SPECIFICATIONS, ON THE DRAWING, AND IN ANY OTHER CONTRACT DOCUMENTS. WHEN A CHANGE IS CALLED FOR ON A DRAWING, THIS CHANGE SHALL CARRY THROUGH ALL APPLICABLE DRAWINGS, INCLUDING ALL RELATED ARCHITECTURAL, CIVIL, STRUCTURAL, MECHANICAL, PLUMBING AND ELECTRICAL DRAWINGS. THE BID/CONTRACT DOCUMENTS ARE HEREBY AMENDED IN THE FOLLOWING PARTICULARS:

1A-2 SPECIFICATIONS

1. **Undesirable Material** (Par. 0210-A5): Add the following: "Assume for bidding purposes that all excavated material on this project will be removed from site."
2. **Porous Fill under Slabs** (Par. 0220-F3): Change "(#67 stone meeting ALDOT specs) to (#67 gradation).

1A-3 DRAWINGS


1. **Parking Lot Striping** (Sht. C1.0): See **Attachment #1** for additional parking lot striping.
2. **Sewer Lateral to Existing Manhole** (Sht. C4.0): See **Attachment #2** for manhole tap.
3. **3" Conduit with 1 ½" PEX** (Sht. P2.1): Adjust location eastward and provide addition sleeve from Bay #110 to Storage #111. See **Attachment #3**.
4. **Additional Wall Hydrants** (Sht. P3.1): Add additional wall hydrants to west end wall. See **Attachment #4**.
5. **Addition Site Power Receptacle** (Sht. E1.1): Add additional power to South-West end of parking area. See **Attachment #5**.

6. **Lighting of Future Office Area under Base Bid** (Sht. E2.1): See **Attachment #6**.
7. **Power of Future Office Area under Base Bid** (Sht. E3.1): See **Attachment #7** for power and shop bays for deletion of four (4) power reels.
8. **Additional EUH-1 for Future Office Area** (Sht. E3.2): See **Attachment #8** for undeveloped area heating under Base Bid.
9. **Location of IDF-1 under Base Bid** (E4.1): See **Attachment #9** for additional Sheet Notes and Plan Notes.
10. **Lighting Fixture Schedule** (Sht. E5.1): See **Attachment #10** for additional scheduled fixture.
11. **Power Riser Diagram** (Sht. E7.1): See **Attachment #11** for deletion of sheet Note #2 shown on Panel "RP1".

1A-4 ATTACHMENTS

Attachment #1 – Parking Lot Striping
Attachment #2 – Sewer Lateral to Existing Manhole
Attachment #3 – 3" Conduit with 1 ½" PEX
Attachment #4 – Additional Wall Hydrants.
Attachment #5 – Additional Site Power
Attachment #6 – Future Office Area Lighting Under Base Bid
Attachment #7 – Future Office Area Power (Under Base Bid) and partial Power Reel
Deletion from contract
Attachment #8 – Future Office Area Base Bid Heating
Attachment #9 – Relocation of IDF-1 under Base Bid
Attachment #10 – Additional Lighting Fixture to Schedule
Attachment 11 – Modified Power Riser Diagram

End of Addendum

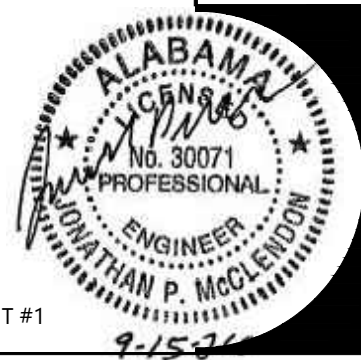


DRAWN:	W.W.
CHECKED:	J.P.M.
DATE:	9.15.26
REVISED	
SHEET TITLE	
REVISED PARKING	
DCM #2025417 PHJ #2502-CUA	
JOB NO.:	
SEC. NO.	OF
SHEET NO.:	

REBID
FOR
A NEW FLEET MANAGEMENT BUILDING
AIDT
MONTGOMERY, ALABAMA

CROWN	
CHECKED	
DATE	
REVISION	
SHEET TITLE	DETAIL
DCM #2025417 PHJ #2502-CUA	
SHEET NO.	OF
SHEET NO.	


MANHOLE SIZING CHART	
MIN. MANHOLE DIAMETER	SEWER DIAMETER
48"	≤ 18"
60"	20" TO 42"
72"	48" TO 54"

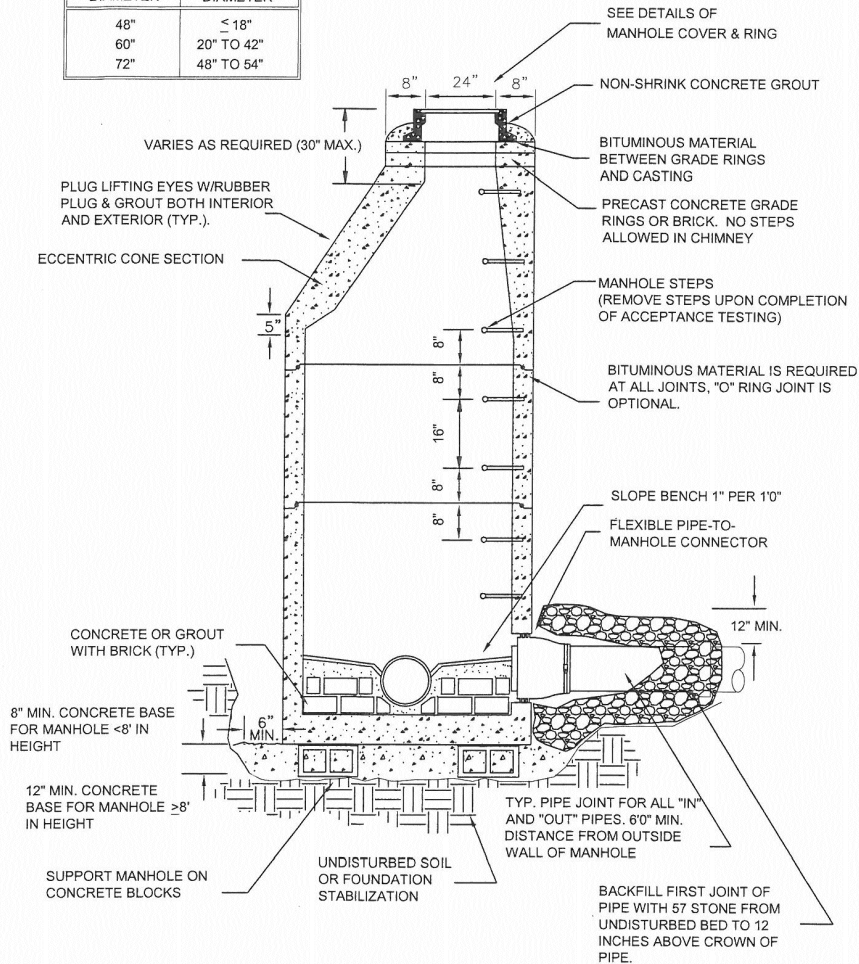

WATER
WORKS & SANITARY SEWER BOARD
Montgomery Alabama

SANITARY SEWER DETAILS

TITLE:	CLASS I PRECAST CONCRETE MANHOLE	DRAWING NO.:	300
DESIGNED:	TL	DATE:	09/00
CHECKED:	HR	REVISED:	01/13
		SCALE:	NOT TO SCALE

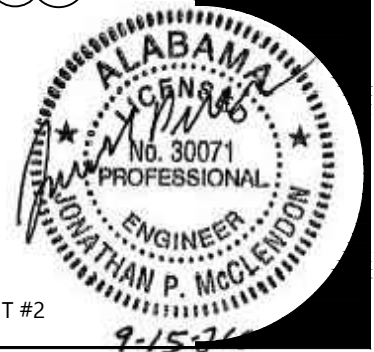



© PH&J ARCHITECTS, INC.
ALL RIGHTS RESERVED

REBID
FOR
AIDT
MONTGOMERY, ALABAMA


A NEW FLEET MANAGEMENT BUILDING

DRAWN: JRE
CHECKED: JRE
DATE: 09-15-26
REVISED: 09-15-26
SHEET TITLE:

DCM #2025417
JOB NO. PHJ #2502-CUA


SEQ. NO. OF
SHEET NO.:


PSD-1

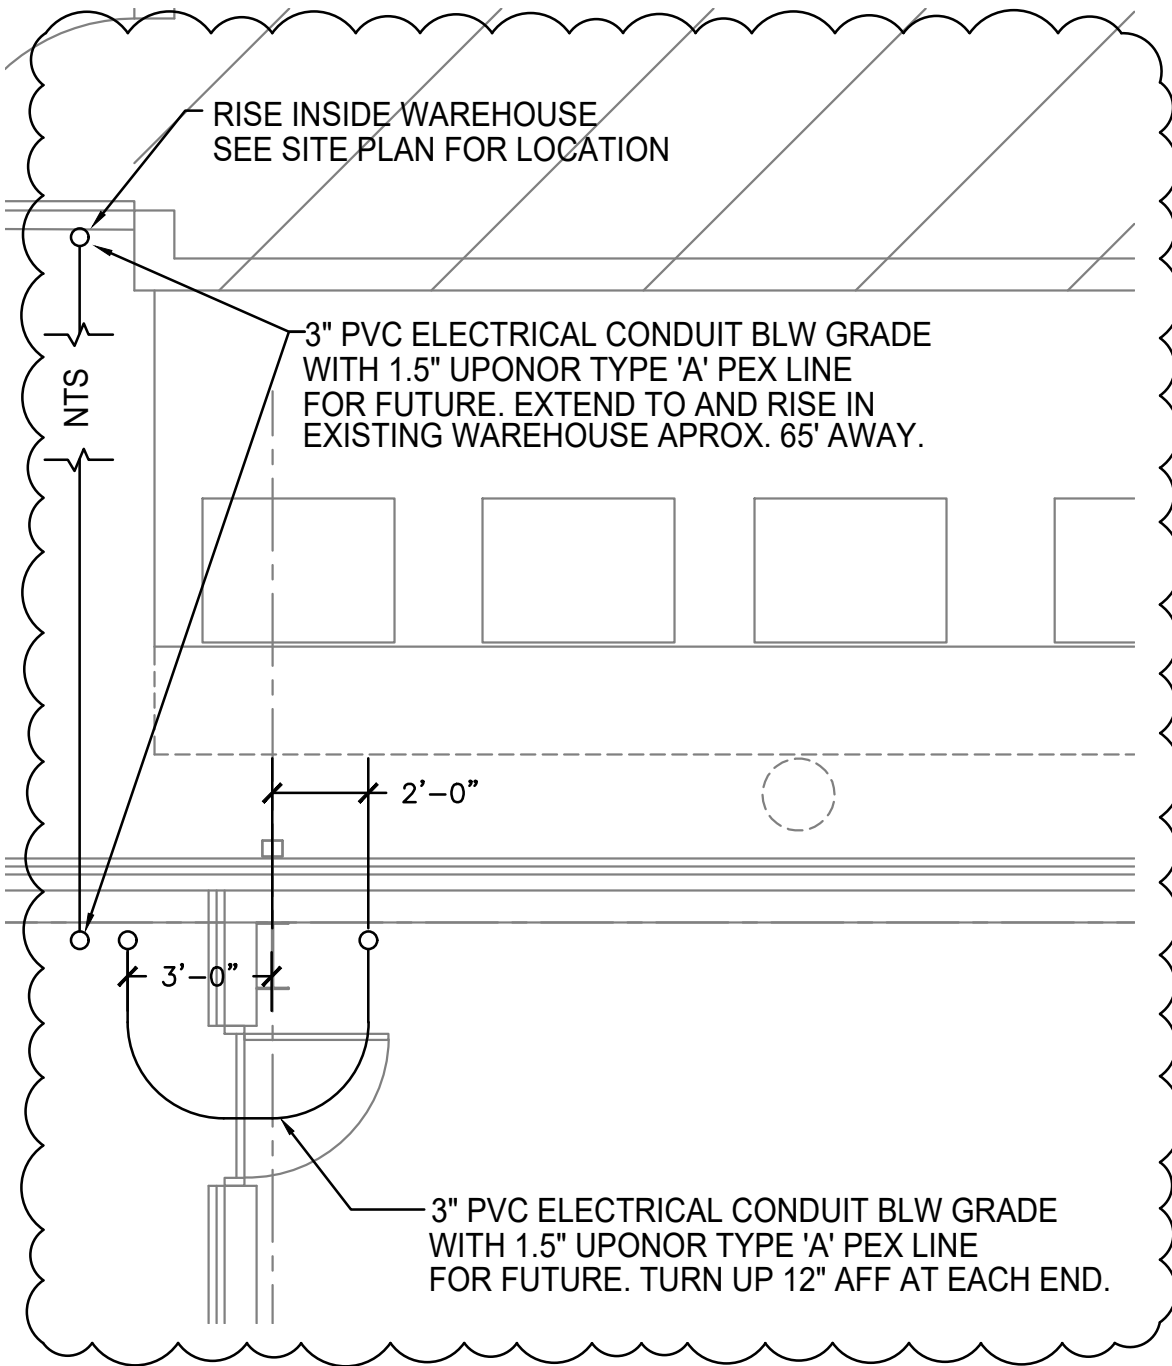

FLOOR PLAN - NON-PRESSURE PIPING

SCALE: 1/4" = 1'-0"

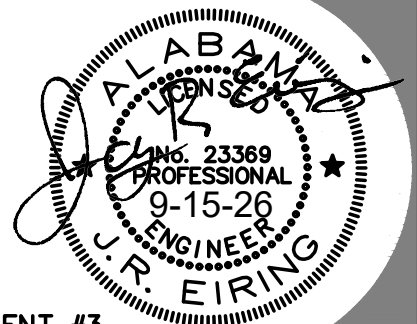

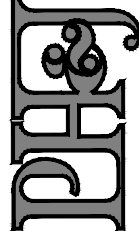

© PH&J ARCHITECTS, INC.
ALL RIGHTS RESERVED


REBID
FOR
AIDT
A NEW FLEET MANAGEMENT BUILDING
MONTGOMERY, ALABAMA

DRAWN	JRE
CHECKED	JRE
DATE	09-15-26
REVISED	09-15-26
SHEET TITLE	

DCM #2025417 PHJ #2502-CUA


SEQ. NO.	OF
SHEET NO.	

PSD-2

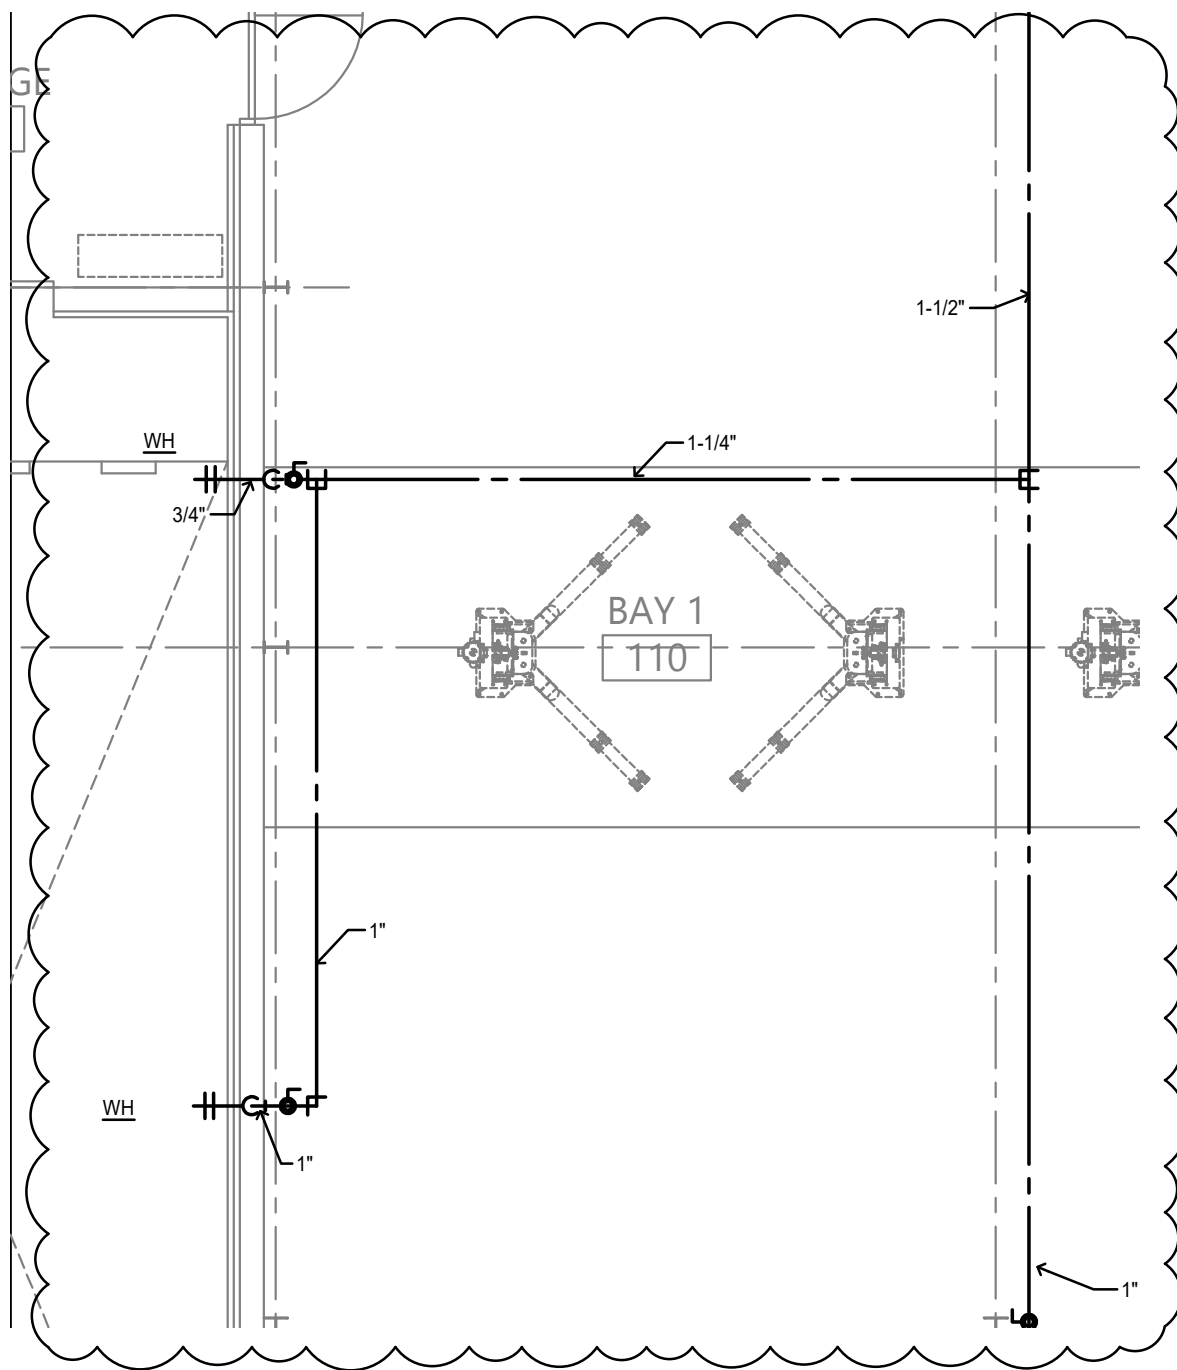

FLOOR PLAN - PRESSURE PIPING

SCALE: 3/16" = 1'-0"

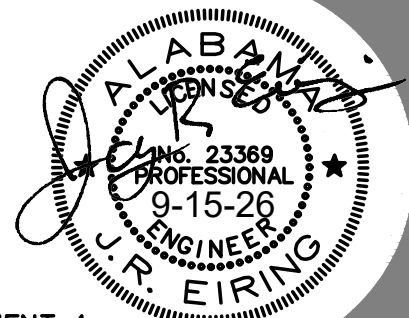

GENERAL NOTES:

1. LOCATIONS OF RISER POLES, AND TRANSFORMERS SHALL BE COORDINATED PRIOR TO BIDS. ADJUST FEEDER AND CONDUIT LENGTHS ACCORDINGLY. PAY ALL UTILITY COMPANY FEES. BID ACCORDINGLY.
2. COORDINATE WITH POWER RISER DIAGRAMS FOR FEEDER AND CONDUIT SIZES AND ALL OTHER ADDITIONAL REQUIREMENTS NOT SHOWN ON SITE PLAN.
3. ALL UNDERGROUND CONDUITS SHALL BE 36" MINIMUM BELOW GRADE. PRIMARY CONDUIT SHALL BE MINIMUM 48" BELOW GRADE.
4. ALL ROUTING IS SHOWN DIAGRAMMATIC. VERIFY ACTUAL ROUTING AND FIELD CONDITIONS PRIOR TO BIDS.
5. CONTRACTOR SHALL LABEL ALL CONDUITS ENTERING AND EXITING COMMUNICATIONS HAND HOLES AND BACKBOARDS.
6. SEE SHEET E1.2 FOR TYPICAL TRENCH/DUCT DETAILS FOR ALL SURFACES. WORK SHALL COMPLY WITH DETAILS.
7. SEE SHEET COMMUNICATIONS RISER DIAGRAMS ON SHEET E6.1 FOR ADDITIONAL REQUIREMENTS.

SHEET NOTES:

- 1

CONTRACTOR SHALL PROVIDE ONE 2" CONDUIT FROM NEW RACK TO EXISTING BUILDING AND THEN LB INTO EXISTING BUILDING AND EXTEND CONDUIT TO EXISTING "MDF" COMMUNICATION'S RACK.
- 2

CONTRACTOR SHALL REMOVE EXISTING EXTERIOR LIGHTING POLE AND LIGHT. CONTRACTOR SHALL INTERCEPT & EXTEND EXISTING CIRCUIT TO EXISTING FIXTURES TO REMAIN. CONTRACTOR SHALL TURN OVER EXISTING POLE AND LIGHTS TO OWNER.
- 3

CONTRACTOR SHALL PROVIDE NEW SECONDARY TO PANEL DH. CONTRACTOR MAY USE EXISTING EXTERIOR JUNCTION BOX CABINET AND SPARE CONDUIT TO EXISTING PANEL DH. CONTRACTOR SHALL VISIT PRIOR TO BIDS TO CONFIRM PATH AND BID ACCORDINGLY.
- 4

CONTRACTOR SHALL VERIFY EXACT NEMA CONFIGURATION WITH OWNER PRIOR TO BIDS FOR PROPER CONNECTION.

SITE LEGEND

- UP--UNDERGROUND PRIMARY
- US--UNDERGROUND SECONDARY
- UC--UNDERGROUND COMMUNICATIONS

UNDERGROUND UTILITY NOTES:

1. THE UNDERGROUND UTILITY PORTION OF THIS PROJECT CONSISTS OF BUT IS NOT LIMITED TO:

a.

TRENCHING/BACKFILLING FOR DUCT LINES AND CONDUIT SYSTEMS

b.

DUCTBANK INSTALLATIONS

c.

LOW VOLTAGE CONDUCTOR INSTALLATION

d.

PATCH/REPAIR ALL DAMAGED SURFACES AS A RESULT OF DUCTLINE INSTALLATIONS
2. INSTALLATION SHALL COMPLY WITH THE REQUIREMENTS OF THE NATIONAL ELECTRICAL SAFETY CODE (NESC) AND THE NATIONAL ELECTRICAL CODE (NEC).
3. ALL CONDUCTIVE PARTS OF EQUIPMENT, ENCLOSURES, SUPPORTS, FRAMES, CASES, CONDUIT SYSTEMS AND SURGE ARRESTORS, CABLE SHEATHS, CABLE SHIELDS, COMMON NEUTRALS, ETC., SHALL BE GROUNDED. UNLESS NOTED OTHERWISE CONNECTIONS BELOW GRADE SHALL BE FUSION-WELDED AND ABOVE GRADE FUSION-WELDED OR BOLTED SOLDERLESS. ALL GROUND CONDUCTORS SHALL BE COPPER.
4. ALL CLEARANCES SHALL BE MAINTAINED PER NESC AND NEC. ALL PARTS, DEVICES, EQUIPMENT, ETC. WHICH REQUIRE MAINTENANCE, ADJUSTMENT, OPERATION OR EXAMINATION DURING NORMAL NETWORK OPERATION SHALL BE ARRANGED SO AS TO BE ACCESSIBLE BY THE PROVISION OF ADEQUATE WORKING SPACES, WORKING FACILITIES AND CLEARANCES. UNLESS NOTED OTHERWISE ALL CLEARANCES ARE MEASURED FROM SURFACE TO SURFACE.
5. ALL DIMENSIONS INDICATED IN THESE DOCUMENTS ARE FOR REFERENCE AND COORDINATION PURPOSES ONLY. THE CONTRACTOR IS RESPONSIBLE FOR VERIFYING ALL DIMENSIONS IN THE FIELD.
6. UNLESS OTHERWISE SHOWN OR DIRECTED DUCT LINES SHALL NOT BE LOCATED DIRECTLY UNDER STRUCTURES AND NOT DIRECTLY UNDER OR OVER OTHER SUBSURFACE STRUCTURES. WHERE DUCT LINES ARE REQUIRED TO CROSS OTHER UTILITIES SUCH AS SEWERS, WATER LINES, OTHER POWER LINES, COMMUNICATION LINES, ETC., ADEQUATE SUPPORT SHALL BE PROVIDED ON EACH SIDE OF THE CROSSING TO PREVENT TRANSFERRING ANY DIRECT LOAD ONTO THE OTHER LINE. DUCT LINES SHALL BE SO INSTALLED AS TO PREVENT HEAT TRANSFER BETWEEN ANY HEAT PRODUCING LINES AND/OR EQUIPMENT TO DUCT LINES.

a.

ROUTING SHOWN ON DRAWINGS IS TYPICAL AND THE CONTRACTOR SHALL PROPOSE FINAL ROUTING BASED UPON ACTUAL FIELD DIMENSIONS, CONDITIONS AND EXISTING UNDERGROUND UTILITIES AND STRUCTURES.

b.

PRIOR TO TRENCHING, THE CONTRACTOR SHALL STAKE OUT THE ENTIRE NETWORK ARRANGEMENT. ONE GRADE A WOODEN STAKE WITH RED FLAG SHALL BE DRIVEN EVERY 50'-0" AND AT EACH CHANGE OF DIRECTION. FOUR STAKES SHALL BE DRIVEN TO OUTLINE EQUIPMENT AND/OR MANHOLE LOCATIONS. ON PAVEMENTS RED PAINT SHALL BE USED TO OUTLINE THE AREAS TO BE CUT. SECURE EXISTING UNDERGROUND UTILITY INFORMATION FROM THE CONTRACTING OFFICER PRIOR TO PERFORMING ANY TRENCHING.

c.

DEPTHS INDICATED FOR INSTALLATION ARE MINIMUM. ACTUAL DEPTHS MAY VARY DUE TO TERMINATIONS, COMPENSATIONS FOR RADIUS OF VERTICAL TRANSITIONS, EXISTING UTILITY CROSSINGS, ETC. APPROVAL SHALL BE OBTAINED FOR ANY DEPTH LESS THAN INDICATED. TRENCHES SHALL BE OVER-EXCAVATED AS NECESSARY TO ALLOW FOR PROPER TRENCH PREPARATION, DUCT BANK CONSTRUCTION, FORMING AND/OR BACKFILLING REQUIREMENTS.

d.

ALL TRENCHING AND BACKFILL COMPACTION SHALL COMPLY WITH GEOTECHNICAL REPORT AND DIVISION 200.

"AIDT PARCEL"
5.36 ACRES
MORE OR LESS
(RLPY 04670, PAGE 0104)


APPROXIMATE LOCATION OF EXISTING
MAIN COMMUNICATION RACK "MDF"

APPROXIMATE LOCATION OF EXISTING
PANEL "DH" 600 AMP, 277/480V, 3Ø, 4W

NEW PANEL "SE"


COMMUNICATION RACK IDF-1

TECHNOLOGY COURT

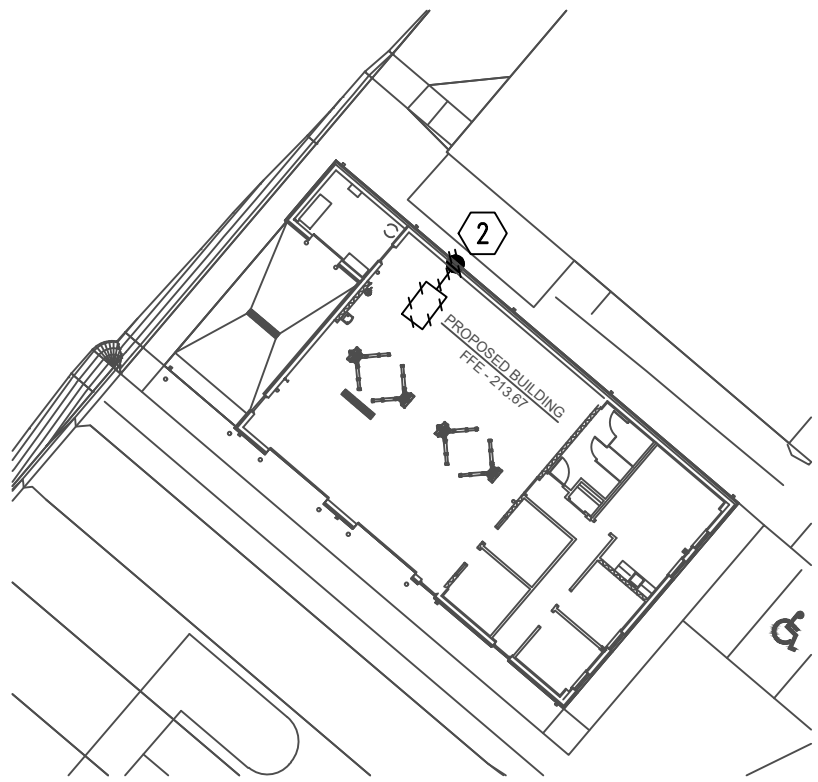

PARTIAL SITE PLAN - ELECTRICAL
SCALE: 1" = 30'-0"


BASE BID SITE PLAN - ELECTRICAL
SCALE: 1" = 30'-0"

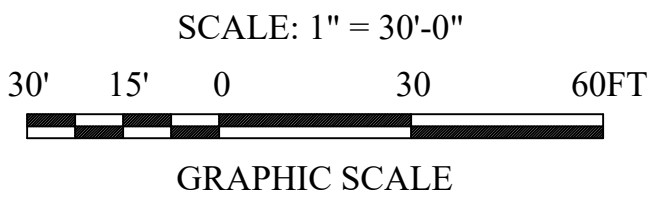

Gunn & Associates, P.C.
Consulting Engineers
3102 Highway 14
Millbrook, AL 36054
Tel: 334.285.1273
1200 Providence Park, Suite 200
Birmingham, AL 35242
GA#25-195

NEW FLEET MANAGEMENT BUILDING

FOR
AIDT
MONTGOMERY, ALABAMA

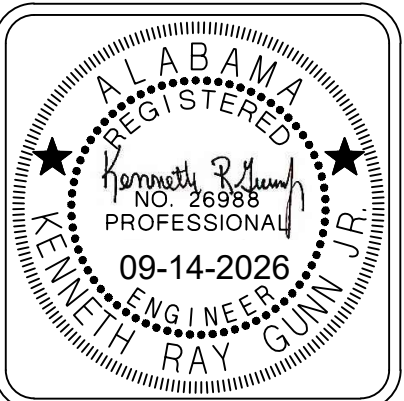

DRAWN	J.C.T.	CHECK	K.R.G.
DATE	8/20/2026 R.T.A.		
REVISED	⚠ 9-14-2026		
REVISED			
SHEET TITLE SITE PLAN - ELECTRICAL			
JOB NO. PH&J #2502-CUA DCM #2025417			
SEQUENCE NO.	28	OF	39

RE-BID
E1.1

ADDENDUM NO.: 1
ATTACHMENT #5
© PH&J ARCHITECTS, INC.
ALL RIGHTS RESERVED

architects inc.
Montgomery,
Alabama

SHEET NOTES:

- ① DUE TO SECURITY CONCERNS THE OWNER DOES NOT WANT CORRIDOR LIGHTS TO TURN OFF DURING CLASS BY OCCUPANCY SENSORS.
- ② ROUTE EXTERIOR LIGHTING CIRCUITS THRU CONTACTORS AS SHOWN IN DETAIL 3. "NL" DESIGNATES LIGHTS ARE PHOTOCELL ON/PHOTOCELL OFF. "OL" DESIGNATES PHOTOCELL ON/TIMECLOCK OFF.
- ③ DUE TO SECURITY CONCERNS THE OWNER DOES NOT WANT SHOP LIGHTS TO TURN OFF DURING USE BY OCCUPANCY SENSORS.
- ④ MOUNT WALL LIGHT TO BE ABLE TO LIGHT CLOSE LIFTS WHEN LIFTS ARE RAISED. MOUNT WALL LIGHT 5 1/2 FEET OR AS DIRECTED BY OWNER.
- ⑤ CONTRACTOR SHALL PROVIDE JUNCTION BOX AND STUB UP BUILDING EXTERIOR LIGHTING POWER AND CONTROLS FOR FUTURE LIGHTS PROVIDED BY OWNER. PROVIDE ALLOWANCE OF \$3,000 FOR EXTERIOR BUILDING LIGHTS. VERIFY EXACT LOCATION WITH OWNER PRIOR TO ROUGH IN.

ROOM CONTROLLER NOTES:


1. CONTRACTOR SHALL LOCATE ALL ROOM CONTROLLERS ABOVE DOORS IN EACH ROOM 6" ABOVE CEILING GRID. PROVIDE ACCESS PANELS WHERE LOCATED ABOVE HARD CEILINGS OR MOUNT IN UTILITY TYPE ROOMS WHENEVER POSSIBLE. ROOM CONTROLLERS SHOWN ON THIS PLAN IS DIAGRAMMATIC FOR CIRCUITRY. DO NOT USE THESE FOR ACTUAL LOCATIONS. PROVIDE A WHITE PHENOLIC LABEL WITH 1" BLACK TEXT THAT READS "RC" GLUED ON CEILING GRID UNDER POWER PACK FOR EACH LOCATION FOR FUTURE MAINTENANCE.

PHOTOCONTROL OF LIGHTING:

1. PHOTOCONTROL OF LIGHT FIXTURES WILL NOT BE REQUIRED FOR THE AREAS ON THIS PAGE. THE PRIMARY SIDELIGHTED AREA WILL NOT HAVE WATTAGES EXCEEDING 150W.

KEYED NOTES


- ① POWER SUPPLY - 120V, 1PH, 60HZ
- ② TIME SWITCH ENCLOSURE - NEMA 1 UNLESS NOTED OTHERWISE
- ③ CONTACTOR ENCLOSURE - NEMA 1 UNLESS NOTED OTHERWISE
- ④ POWER TAP TO PHOTO-CELL IN GRC
- ⑤ TURN-LOCK PHOTO-CELL, SEE DETAIL
- ⑥ SWITCH LEG RETURN IN GRC
- ⑦ POWER TO CONTACTOR COIL
- ⑧ LIGHTING CONTACTOR [C] NL & [C] OL AS FOLLOWS:
- NEMA ICS 2-211B INDUSTRIAL DUTY TYPE
-ELECTRICALLY OPERATED-ELECTRICALLY HELD
-RATING AND NUMBER OF POLES INDICATED
-CONTACTS SHALL BE SILVER ALLOY, DOUBLE-BREAK, SUITABLE FOR TUNGSTEN, BALLAST LIGHTING, RESISTANCE AND MOTOR LOADS
-FUSING FOR CONTROL CIRCUIT
- ⑨ GROUND CONDUCTOR - BOND TO EACH ENCLOSURE AND INSTALL IN EACH CONDUIT SYSTEM
- ⑩ DIGITAL TIME SWITCH AS FOLLOWS:
- ONE CHANNEL WITH 24 HOUR, SEVEN DAY PROGRAMMING AND SKIP-A-DAY FEATURE
-INPUT: 120 VAC, 60HZ
-OUTPUT: DPST DRY CONTACTS (UNPOWERED)
-HEAVY DUTY CONTACTS RATED 20 AMPERE RESISTIVE AT 120 VAC
-TEMPERATURE RANGE: -20 TO +60 DEGREES CELSIUS
-RELATIVE HUMIDITY: 0 TO 90% RH
-CLOCK ACCURACY: ±2 MINUTES PER YEAR
-LED INDICATION OF TIME AND LOAD STATUS
-FULL WEEK'S RESERVE POWER (BATTERY BACK-UP)
- ⑪ PROVIDE NUMBER OF POLES REQUIRED.

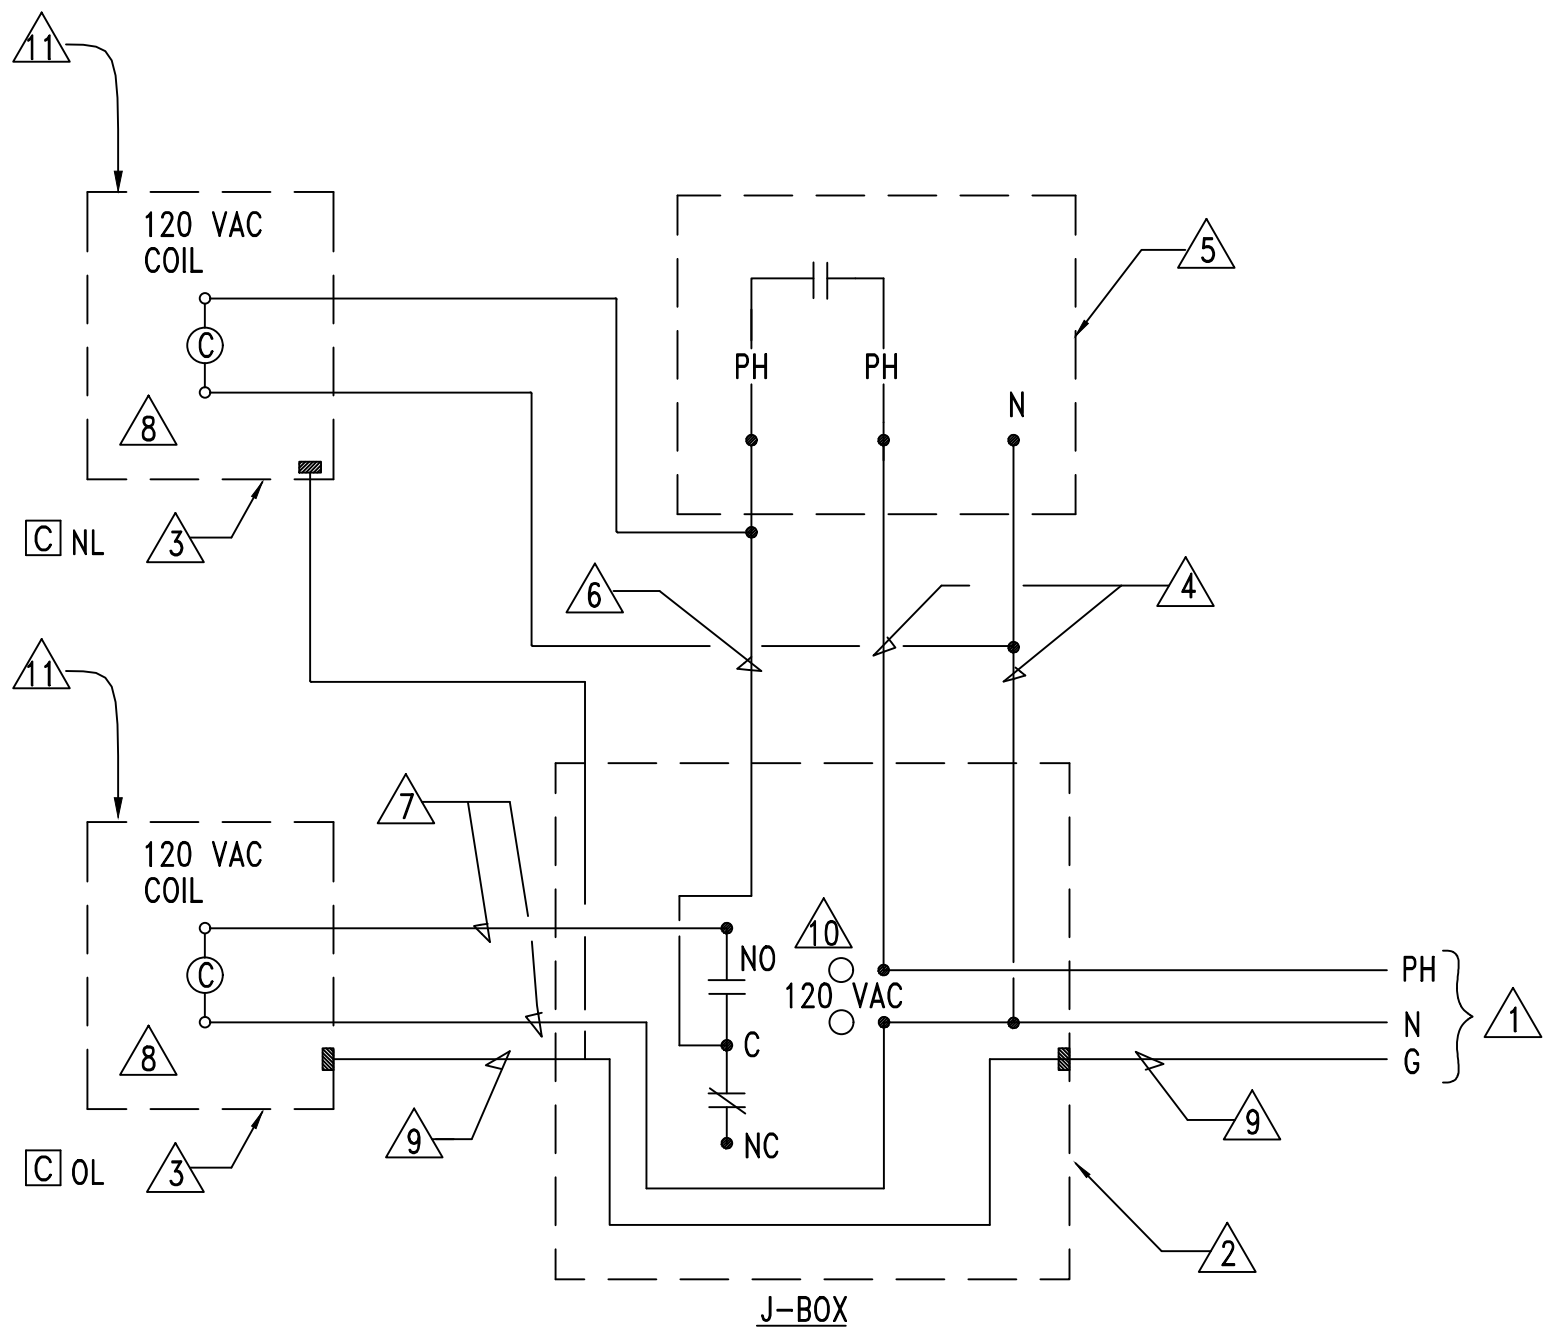

2 DETAIL - TYPICAL OPERATION OF TIME SWITCH/PHOTO-CELL/CONTACTOR
E2.1 NO SCALE

GENERAL NOTES:

1. ALL OCCUPANCY SENSORS LOCATIONS ARE APPROXIMATE, REFER TO MANUFACTURER'S INSTALLATION INSTRUCTIONS FOR EXACT MOUNTING AND SPACING REQUIREMENTS PRIOR TO INSTALLATION.
2. ULTRASONIC CEILING MOUNTED OCCUPANCY SENSORS SHALL BE LOCATED A MINIMUM OF SIX (6) FEET FROM HVAC SUPPLY/RETURN VENTS.
3. CONTRACTOR IS RESPONSIBLE FOR PROPER SENSITIVITY AND TIME DELAY SETTINGS FOR OCCUPANCY SENSORS, FOLLOWING THE MANUFACTURER'S RECOMMENDED PLACEMENT, AND FIELD VERIFICATION OF CIRCUITS WITH RESPECT TO POWER PACK PLACEMENT.
4. CONTRACTOR IS RESPONSIBLE FOR FIELD VERIFICATION OF REQUIRED NUMBER OF POWER PACKS FOR OCCUPANCY SENSORS AND THE FOLLOWING:
- a. ONE POWER PACK IS REQUIRED FOR EACH CONTROLLED CIRCUIT.
- b. REFER TO MANUFACTURER'S INSTALLATION GUIDE FOR MAXIMUM NUMBER OF SENSORS CONNECTED TO A POWER PACK
- c. IF MULTIPLE CIRCUITS OR DUAL SWITCHING ARE TO BE CONTROLLED BY OCCUPANCY SENSORS, PROVIDE ALL ADDITIONAL AUXILIARY RELAYS AND POWER PACKS AS NEEDED.
5. OCCUPANCY SENSORS MOUNTED OVER DOORWAYS SHALL BE PLACED ONE (1) FOOT INSIDE THRESHOLD.
6. SEE POWER PLANS FOR PANEL LOCATIONS.
7. PROVIDE DEDICATED NEUTRALS FOR EACH MULTIWIRED HOMERUN PER NEC.
8. CONTRACTOR SHALL PROVIDE DEDICATED NEUTRALS FOR EACH DIMMING CIRCUIT.
9. COORDINATE WITH LIGHTING CONTROL DETAILS FOR ADDITIONAL REQUIREMENTS. SEE SHEETS E2.2 & E2.3 FOR ADDITIONAL REQUIREMENTS.

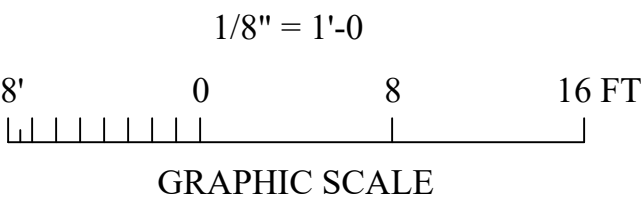

GA Gunn & Associates, P.C.
Consulting Engineers
3102 Highway 14
Millbrook, AL 36054
Tel: 334.285.1273

1200 Providence Park, Suite 200
Birmingham, AL 35242
GA#25-195

RE-BID
E2.1

ADDENDUM NO.: 1
ATTACHMENT #6
© PH&J ARCHITECTS, INC.
ALL RIGHTS RESERVED

NEW FLEET MANAGEMENT BUILDING

FOR
AIDT
MONTGOMERY, ALABAMA

architects inc.
Montgomery,
Alabama



DRAWN	J.C.T.	CHECK	K.R.G.
DATE	8/20/2026	R.T.A.	
REVISED	9-14-2026		
REVISED			

SHEET TITLE
LIGHTING CONTROL
DETAILS - ALTERNATE #2

JOB NO. PH&J #2502-CUA
DCM #2025417


SEQUENCE
NO. 30 OF 39

GENERAL NOTES:


1. PROVIDE DEDICATED NEUTRALS FOR EACH MULTIWIRE HOMERUN PER NEC.
2. COORDINATE EXACT LOCATION OF ALL ELECTRICAL AND COMMUNICATIONS DEVICES WITH MILLWORK PROVIDERS PRIOR TO ROUGH-IN.
3. ALL DISCONNECTS TO HAVE NAMEPLATE AS SHOWN IN DETAIL, NO EXCEPTIONS.
4. ALL RECEPTACLE CIRCUITS THAT ARE ROUTED UNDERGROUND SHALL BE STUBBED UP ABOVE CEILING IN AN ACCESSIBLE LOCATION FOR FUTURE USE.
5. THE OWNER TAKES EXCEPTION TO THE FOLLOWING SECTIONS OF 2013 ASHRAE 90. SECTION 8.4.2 AUTOMATIC RECEPTACLE CONTROLS AND SECTION 8.4.3 ELECTRICAL ENERGY MONITORING. THESE REQUIREMENTS WILL NOT BE PROVIDED IN THIS PROJECT.

SHEET NOTES:

- 1 MOUNT RECEPTACLE AT HEIGHT NEEDED FOR COMM RACK.
- 2 ALL CONVENIENCE RECEPTACLES IN ALL BAY AREAS SHALL BE INSTALLED AT 50" ABOVE FINISHED FLOOR. ALL WIRING AND EQUIPMENT SHALL ALSO COMPLY WITH APPLICABLE PROVISIONS OF NEC 511.
- 3 COORDINATE ROUGH IN LOCATION WITH LIFT PROVIDER PRIOR TO BIDS.
- 4 VERIFY EXACT LOCATION OF INVERTER WELDER WITH OWNER PRIOR TO ROUGH IN.
- 5 POWER FOR ELECTRIC DOOR STRIKE.

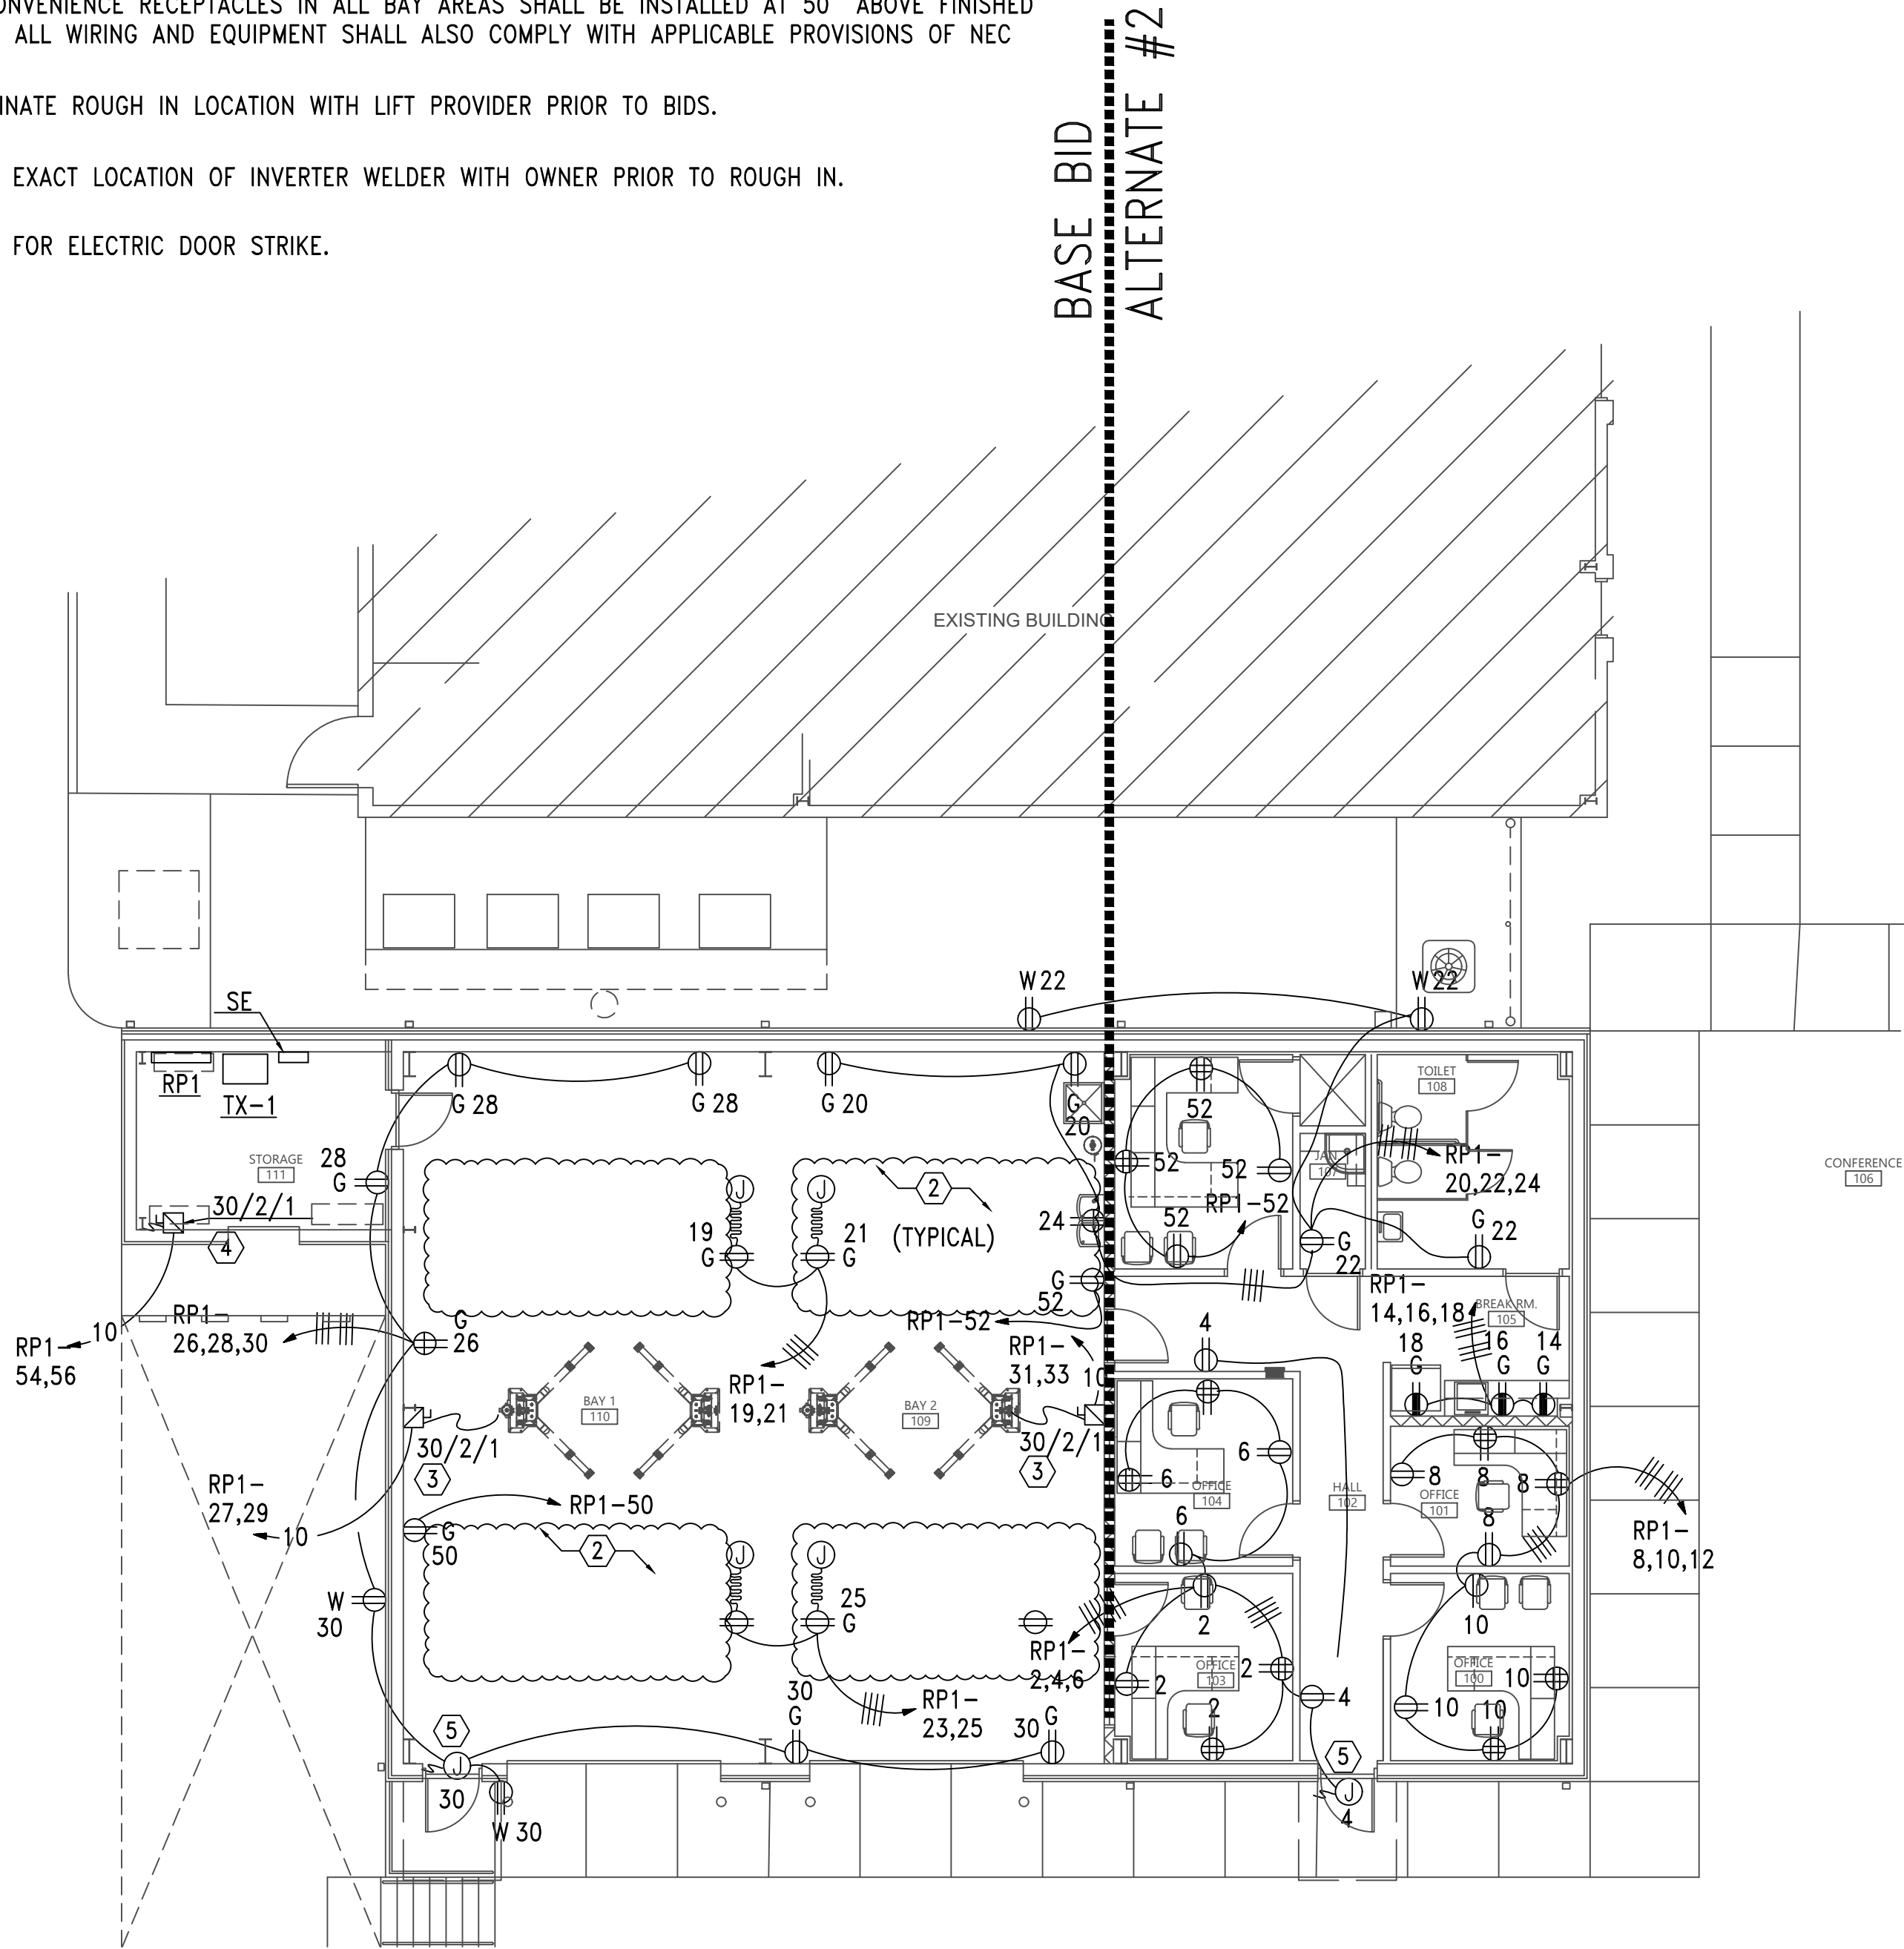


1 FLOOR PLAN - POWER
SCALE: 1/8"=1'-0"

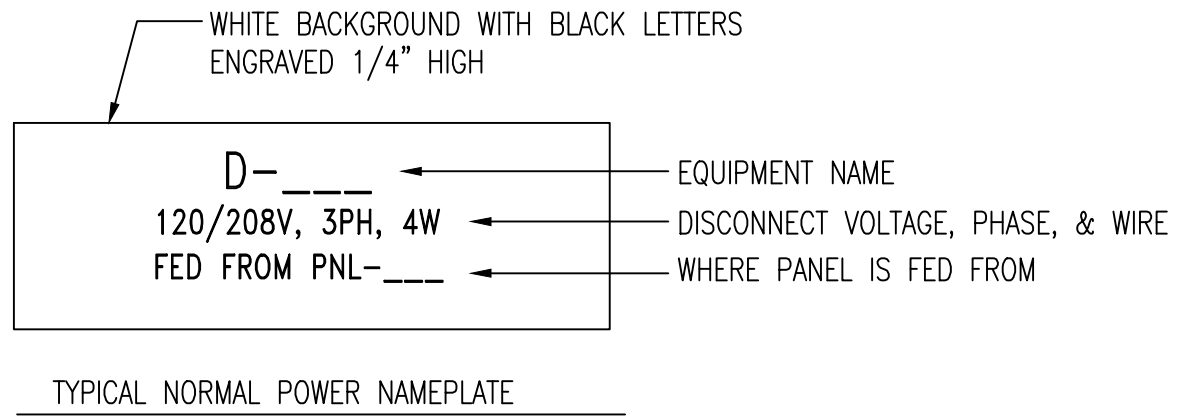

TYPICAL NORMAL POWER NAMEPLATE



2 DETAIL - TYPICAL DISCONNECT NAMEPLATE
NO SCALE

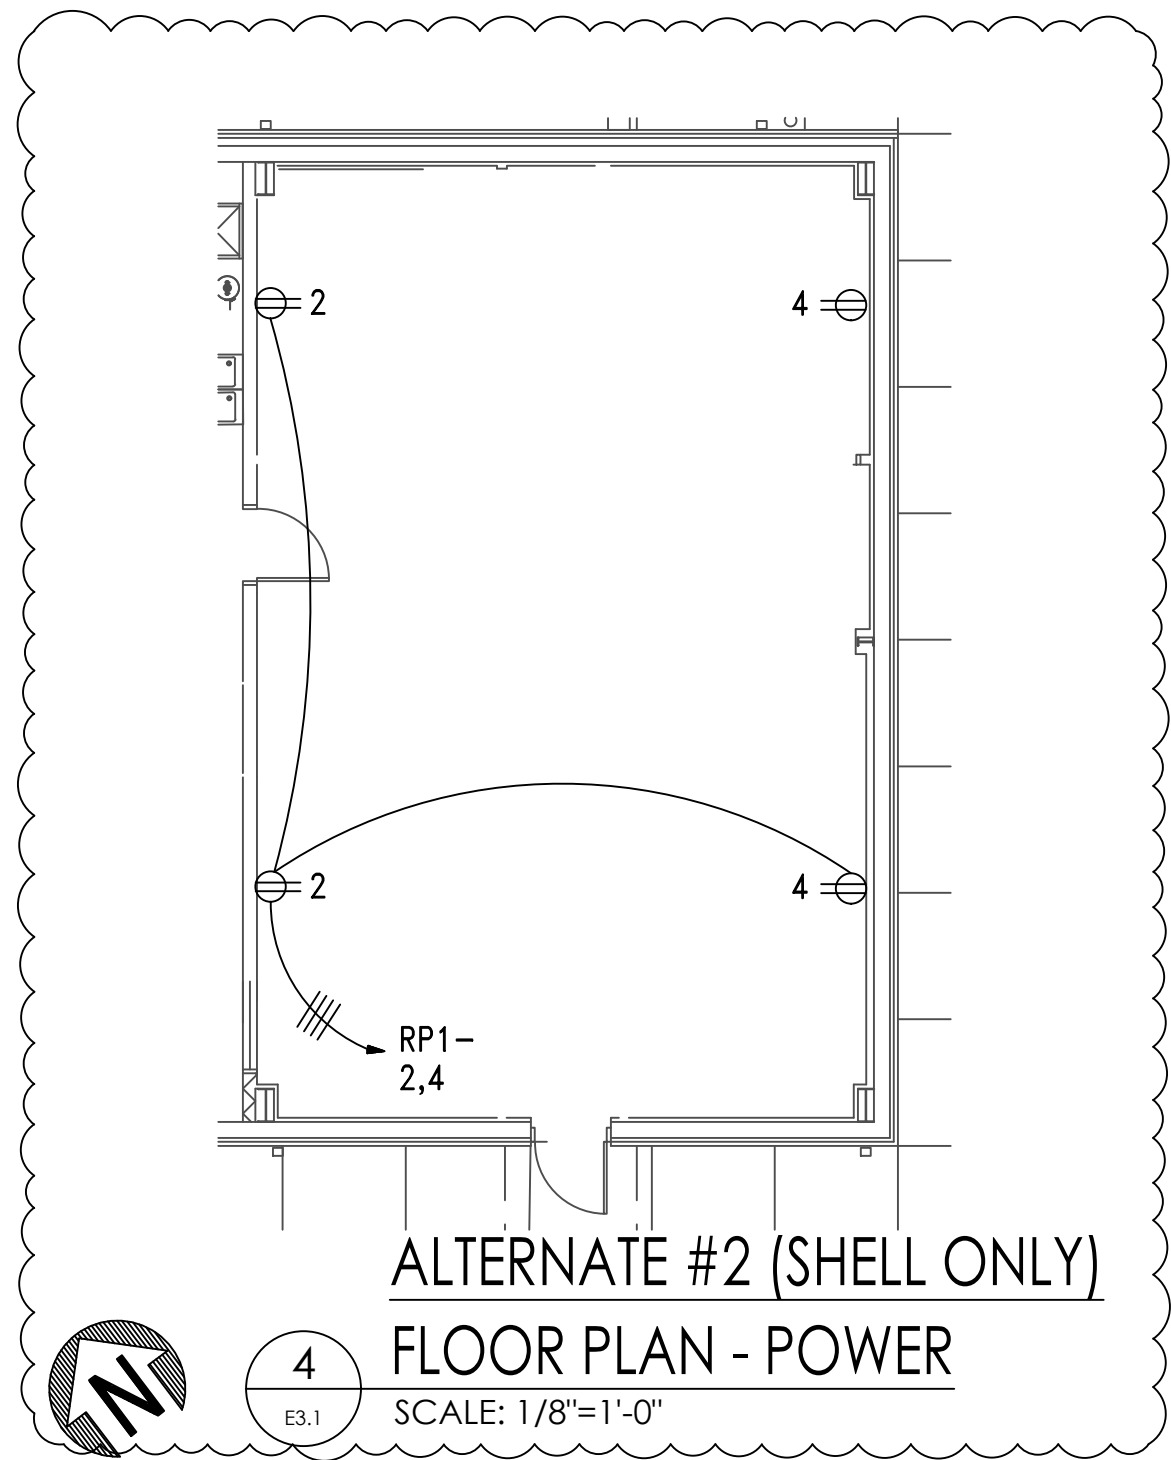


ALTERNATE #2 (SHELL ONLY)

4 FLOOR PLAN - POWER

SCALE: 1/8"=1'-0"



3 PARTIAL FLOOR PLAN - POWER
SCALE: 1/8"=1'-0"

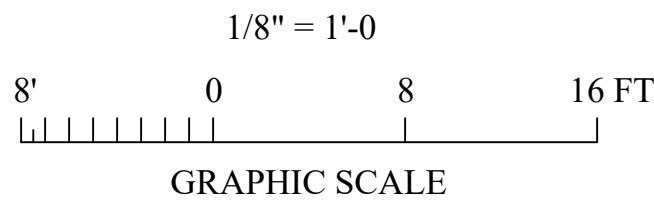

Gunn & Associates, P.C.
Consulting Engineers
3102 Highway 14
Millbrook, AL 36054
Tel: 334.285.1273
1200 Providence Park, Suite 200
Birmingham, AL 35242
GA#25-195

NEW FLEET MANAGEMENT BUILDING

FOR

AIDT

MONTGOMERY, ALABAMA



DRAWN	J.C.T.	CHECK	K.R.G.
DATE	8/20/2026 R.T.A.		
REVISED	9-14-2026		
REVISED			
SHEET TITLE	FLOOR PLAN - POWER		
JOB NO.	PH&J #2502-CUA DCM #2025417		
SEQUENCE NO.	33 OF 39		



RE-BID
E3.1
ADDENDUM NO.: 1
ATTACHMENT #7
© PH&J ARCHITECTS, INC.
ALL RIGHTS RESERVED

architects inc.
Montgomery,
Alabama

GENERAL EQUIPMENT SCHEDULE									
EQUIPMENT MARK:	EQUIPMENT DESCRIPTION:	VOLTAGE/PHASE:	ELECTRICAL CHARACTERISTICS:			DISCONNECT:	FUSE:	HOMERUN:	FEEDER:
			HP	KW	AMPS				
AC-1	INDOOR HEAT PUMP	208V/3PH	----	7.2	28	30/3/1	F	RP1 - 55,57,59	3#10 & 1#10GRD - 3/4"C
CEF-1	EXHAUST FAN	120V/1PH	----	0.1	----	TS	----	RP1 - 49	2#12 & 1#12GRD - 3/4"C
CEF-2	EXHAUST FAN	120V/1PH	----	0.1	----	TS	----	RP1 - 49	2#12 & 1#12GRD - 3/4"C
CON-1	CONTROL PANEL	120V/1PH	----	0.600	----	TS	----	RP1 - 17	2#12 & 1#12GRD - 3/4"C
CU-1	OUTSIDE HEAT PUMP	208V/3PH	----	----	14	30/3/3R	F	RP1 - 44,46,48	3#10 & 1#10GRD - 3/4"C
EF-1	EXHAUST FAN	120V/1PH	1/3	----	----	TS	----	RP1 - 15	2#12 & 1#12GRD - 3/4"C
EF-2	INDOOR HEAT PUMP	208V/3PH	5	----	----	30/3/1	F	RP1 - 43,45,47	3#10 & 1#10GRD - 3/4"C
EUH-1	ELECTRIC UNIT HEATER	208V/1PH	5	----	----	30/2/1	F	RP1 - 37,39	2#10 & 1#10GRD - 3/4"C
EUH-2	ELECTRIC UNIT HEATER	208V/1PH	5	----	----	30/2/1	F	RP1 - 73,75	2#10 & 1#10GRD - 3/4"C
TP-1	TRAP PRIMER	120V/1PH	----	0.600	----	TS	----	RP1 - 38	2#12 & 1#12GRD - 3/4"C
WH-1	(GAS) WATER HEATER	120V/1PH	----	0.600	----	TS	----	RP1 - 36	2#12 & 1#12GRD - 3/4"C
NOTES: 1. COORDINATE WITH MANUFACTURER'S CUTSHEETS OR NAMEPLATE DATA AND ADJUST OVERCURRENT PROTECTION AS NEEDED TO PROTECT EQUIPMENT PER MANUFACTURER'S RECOMMENDATIONS AND TO COMPLY WITH NEC AND ALL LOCAL CODES. COORDINATION SHALL BE DONE PRIOR TO BIDS AND ACCOUNTED FOR IN THE CONTRACTOR'S BID PRICE. 2. ALL DISCONNECTS SHALL BE HEAVY DUTY TYPE. 3. ALL FUSES SHALL BE SIZED PER NAMEPLATE DATA. 4. "NF" - NON-FUSED 5. "F" - FUSED 6. "TS" MANUAL MOTOR STARTER WITH THERMAL OVERLOAD ("W" - WEATHERPROOF) ("30-AMP" - 30-AMP RATED) 7. PROVIDE INTERCONNECTING RELAY SUCH THAT FAN IS CONTROLLED BY LIGHTING. 8. "WP" - WEATHERPROOF ENCLOSURE. 9. CONTRACTOR SHALL COORDINATE EXACT REQUIREMENTS AND LOCATIONS FOR ALL CIRCULATING PUMPS AND TIME CLOCKS WITH MECHANICAL CONTRACTOR PRIOR TO ROUGH-IN.									

SHEET NOTES:


- 1 PROVIDE INTERCONNECTING RELAY TRANSFORMER TO CONTROL 120V EXHAUST FAN ON/OFF BY THE 277 VOLT LIGHTING CIRCUIT IN THIS ROOM. TRANSFORMER SHALL BE 277V INPUT, 120V OUTPUT, 1,000 VA.

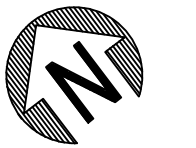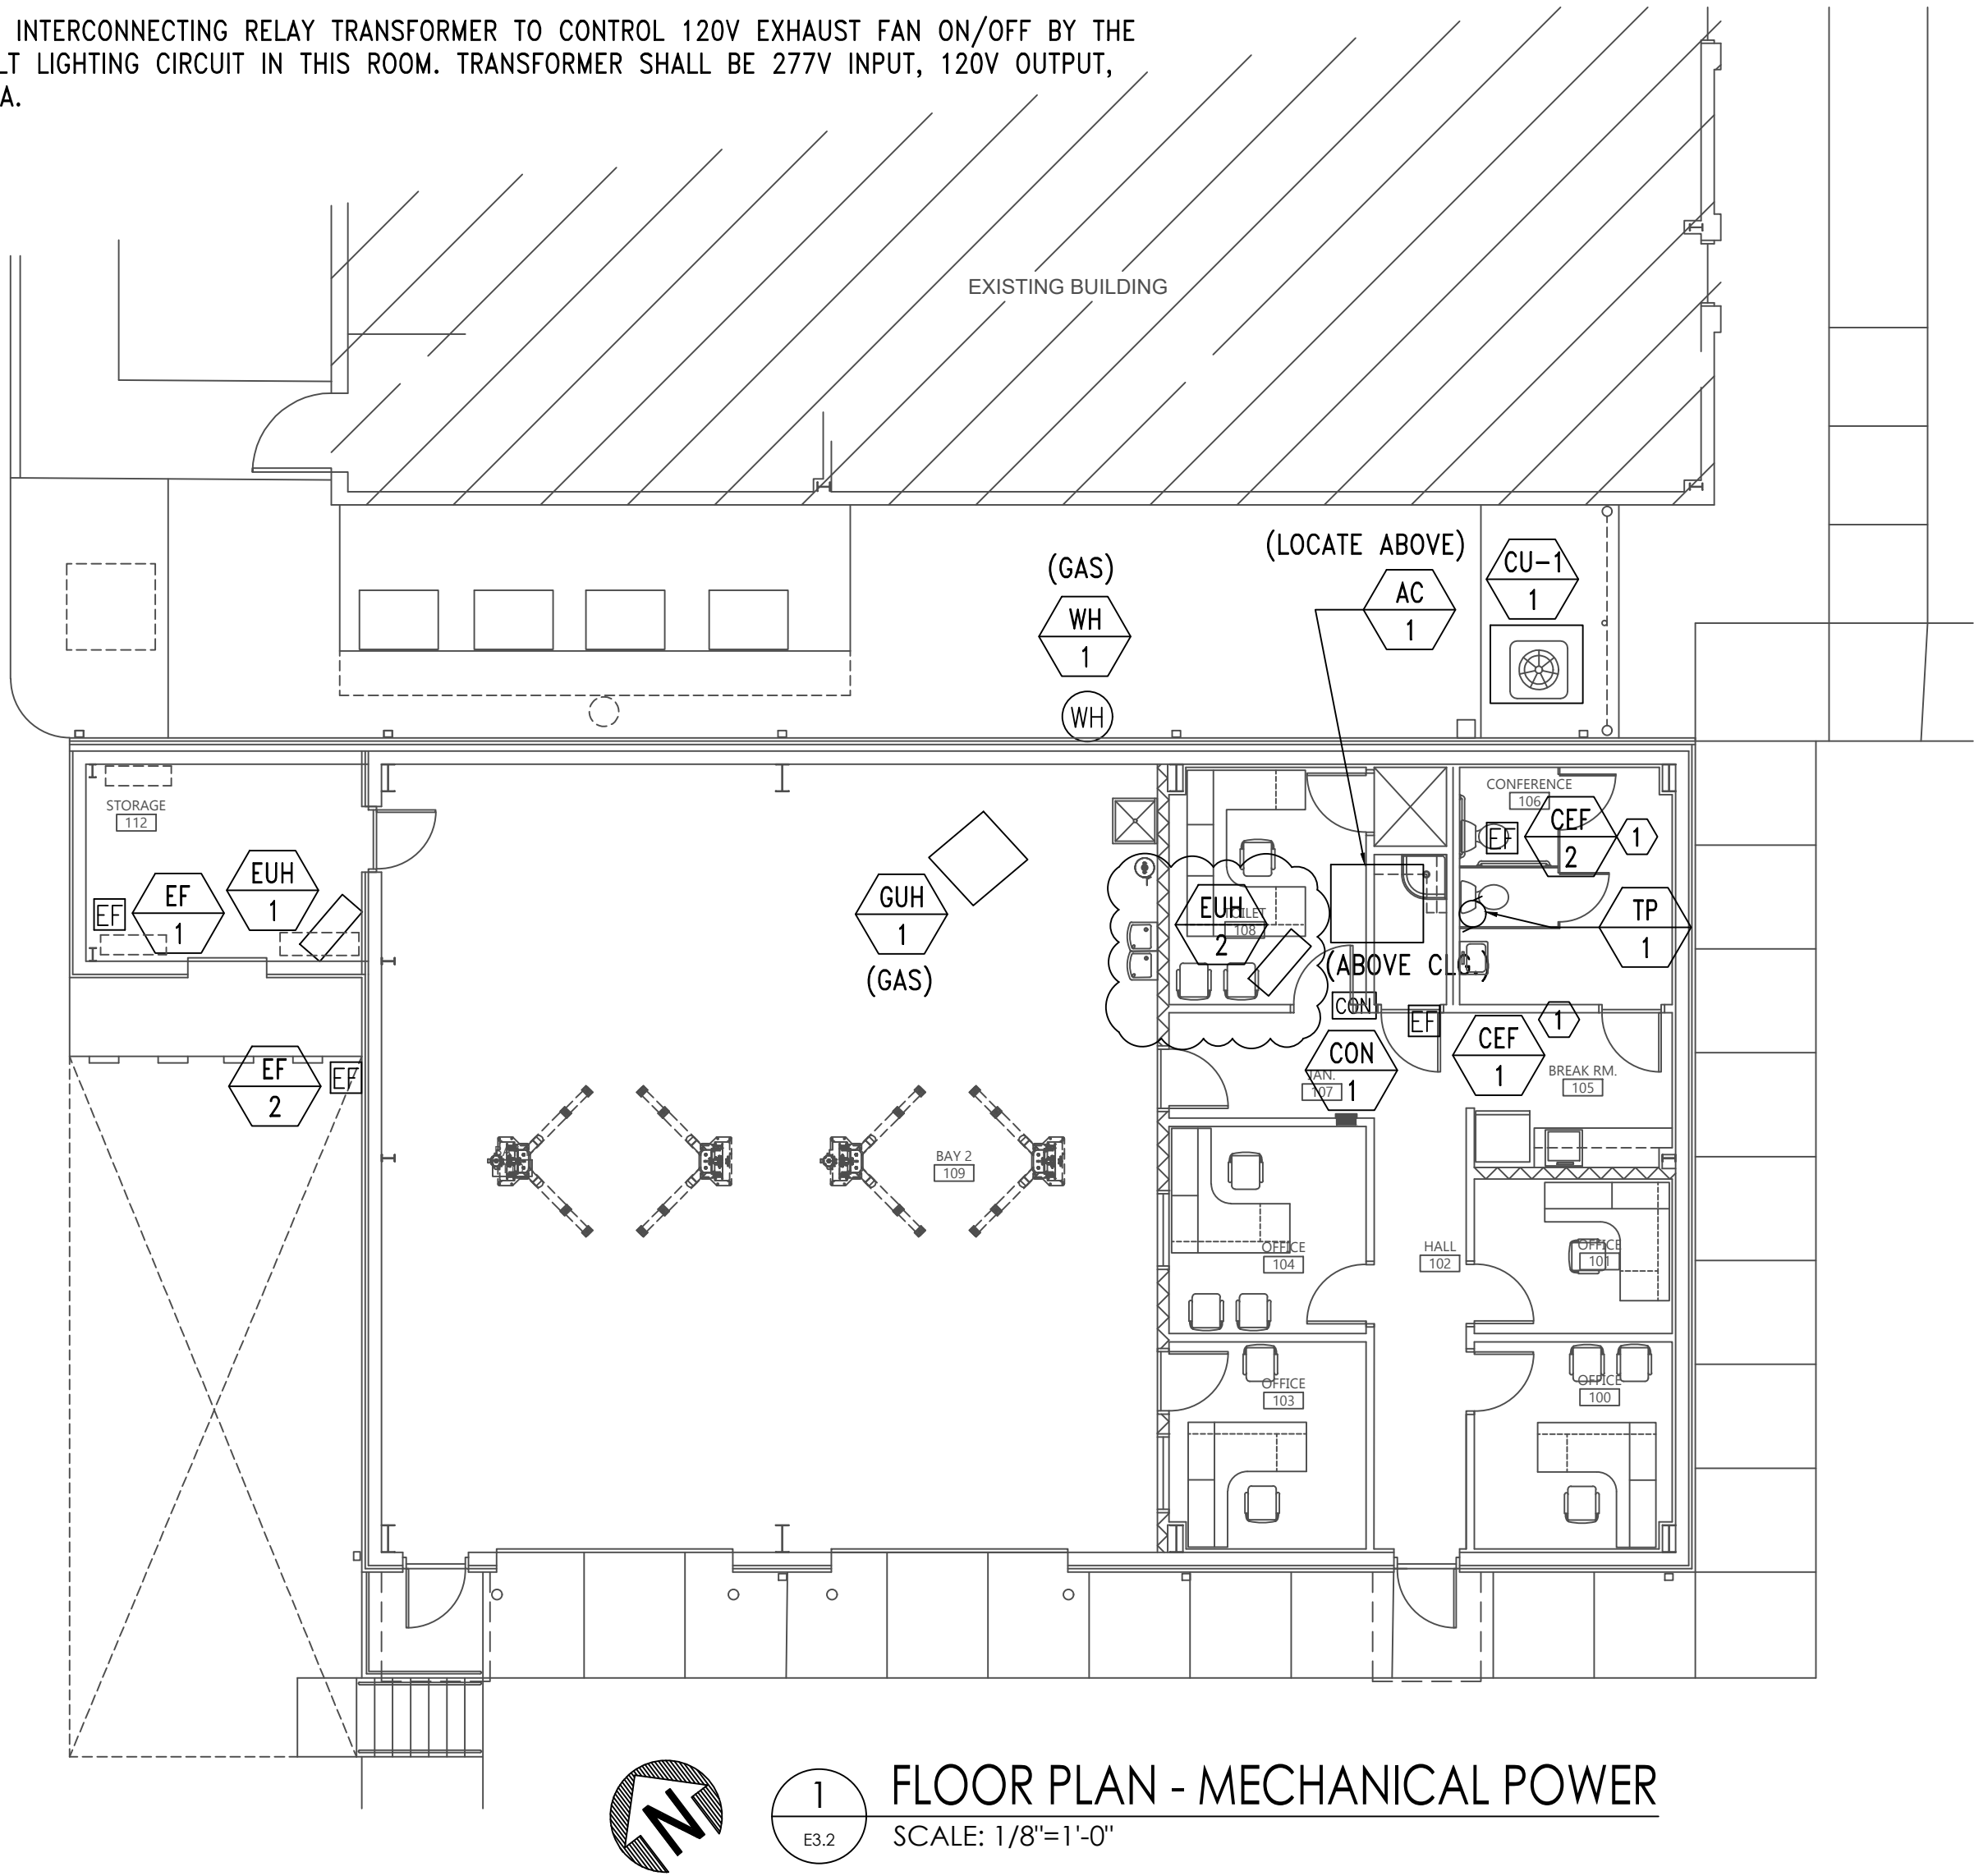

1 FLOOR PLAN - MECHANICAL POWER
SCALE: 1/8"=1'-0"


GENERAL MECHANICAL POWER NOTES:

- COORDINATE WITH MECHANICAL/PLUMBING DRAWINGS FOR EXACT LOCATIONS OF EQUIPMENT.
- MOUNT EXTERIOR DISCONNECTS ON EXTERIOR WALLS AT LEAST 18" FROM WINDOWS. LOCATIONS OF DISCONNECTS AND EQUIPMENT ARE SHOWN FOR DRAWING CLARITY PURPOSES ONLY.
- COORDINATE WITH MECHANICAL/PLUMBING CONTRACTORS TO INSURE OVERCURRENT PROTECTION DEVICES FOR THEIR EQUIPMENT IS SIZED PER MANUFACTURER'S RECOMMENDATIONS. ENGINEER SIZED OVERCURRENT PROTECTION ACCORDING TO MECHANICAL/PLUMBING DRAWINGS AND SPECIFICATIONS, ACTUAL EQUIPMENT SUPPLIED MAY DIFFER. ELECTRICAL CONTRACTOR SHALL WORK WITH OTHER TRADE DISCIPLINES TO INSURE ANY CHANGES WILL BE INSTALLED CORRECTLY AT THE COST OF THE PERSON MAKING THE CHANGES.
- ALL FLEXIBLE CONNECT TO HVAC UNITS SHALL BE RUN PARALLEL TO HARD SURFACE AND STRAPPED AT LEAST EVERY 2'.
- CONTRACTOR SHALL PROVIDE CONDUIT FOR MECHANICAL CONTROLS. COORDINATE EXACT LOCATIONS WITH MECHANICAL CONTRACTOR PRIOR TO ROUGH-IN.
- ALL DISCONNECTS TO HAVE NAMEPLATE AS SHOWN IN DETAIL (2) THIS SHEET, NO EXCEPTIONS.
- PROVIDE DEDICATED NEUTRALS FOR EACH MULTIWIRE HOMERUN PER NEC.
- COORDINATE WITH GENERAL EQUIPMENT SCHEDULES ON THIS SHEET FOR CIRCUITRY OF ALL EQUIPMENT TAGGED ON THIS SHEET.
- SEE DETAIL (3) THIS SHEET FOR MECHANICAL UNIT CONNECTION DETAIL.

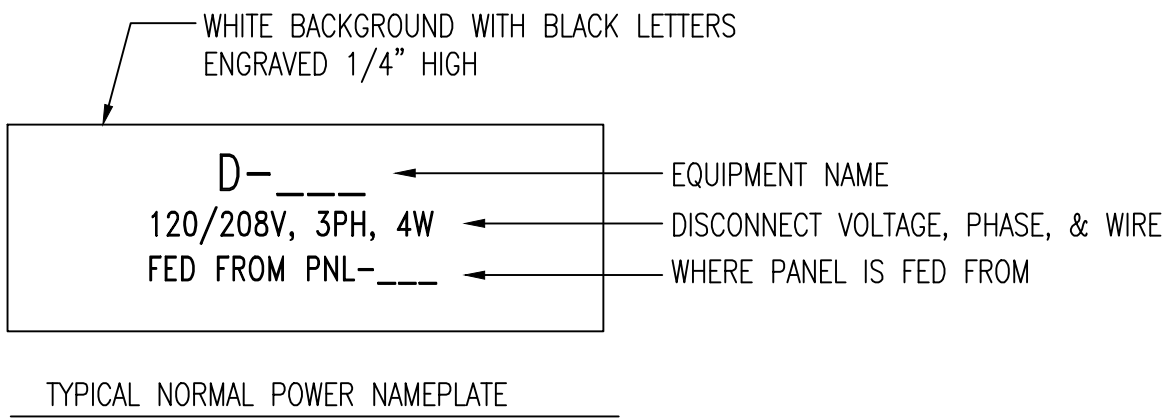

2 DETAIL - TYPICAL DISCONNECT NAMEPLATE
NO SCALE

- NOTE:
- FOR DISTANCE GREATER THAN 48" CONDUIT TO BE ROUTED BELOW GRADE WITH 6" OF MECH. UNIT, STUB-UP W/ RIGID ELBOW THRU CONCRETE PAD. PROVIDE FLEXIBLE CONNECTION FROM ELBOW TO MECH. UNIT, W/ CONNECTION MADE AT UNIT AS SHOWN ABOVE.

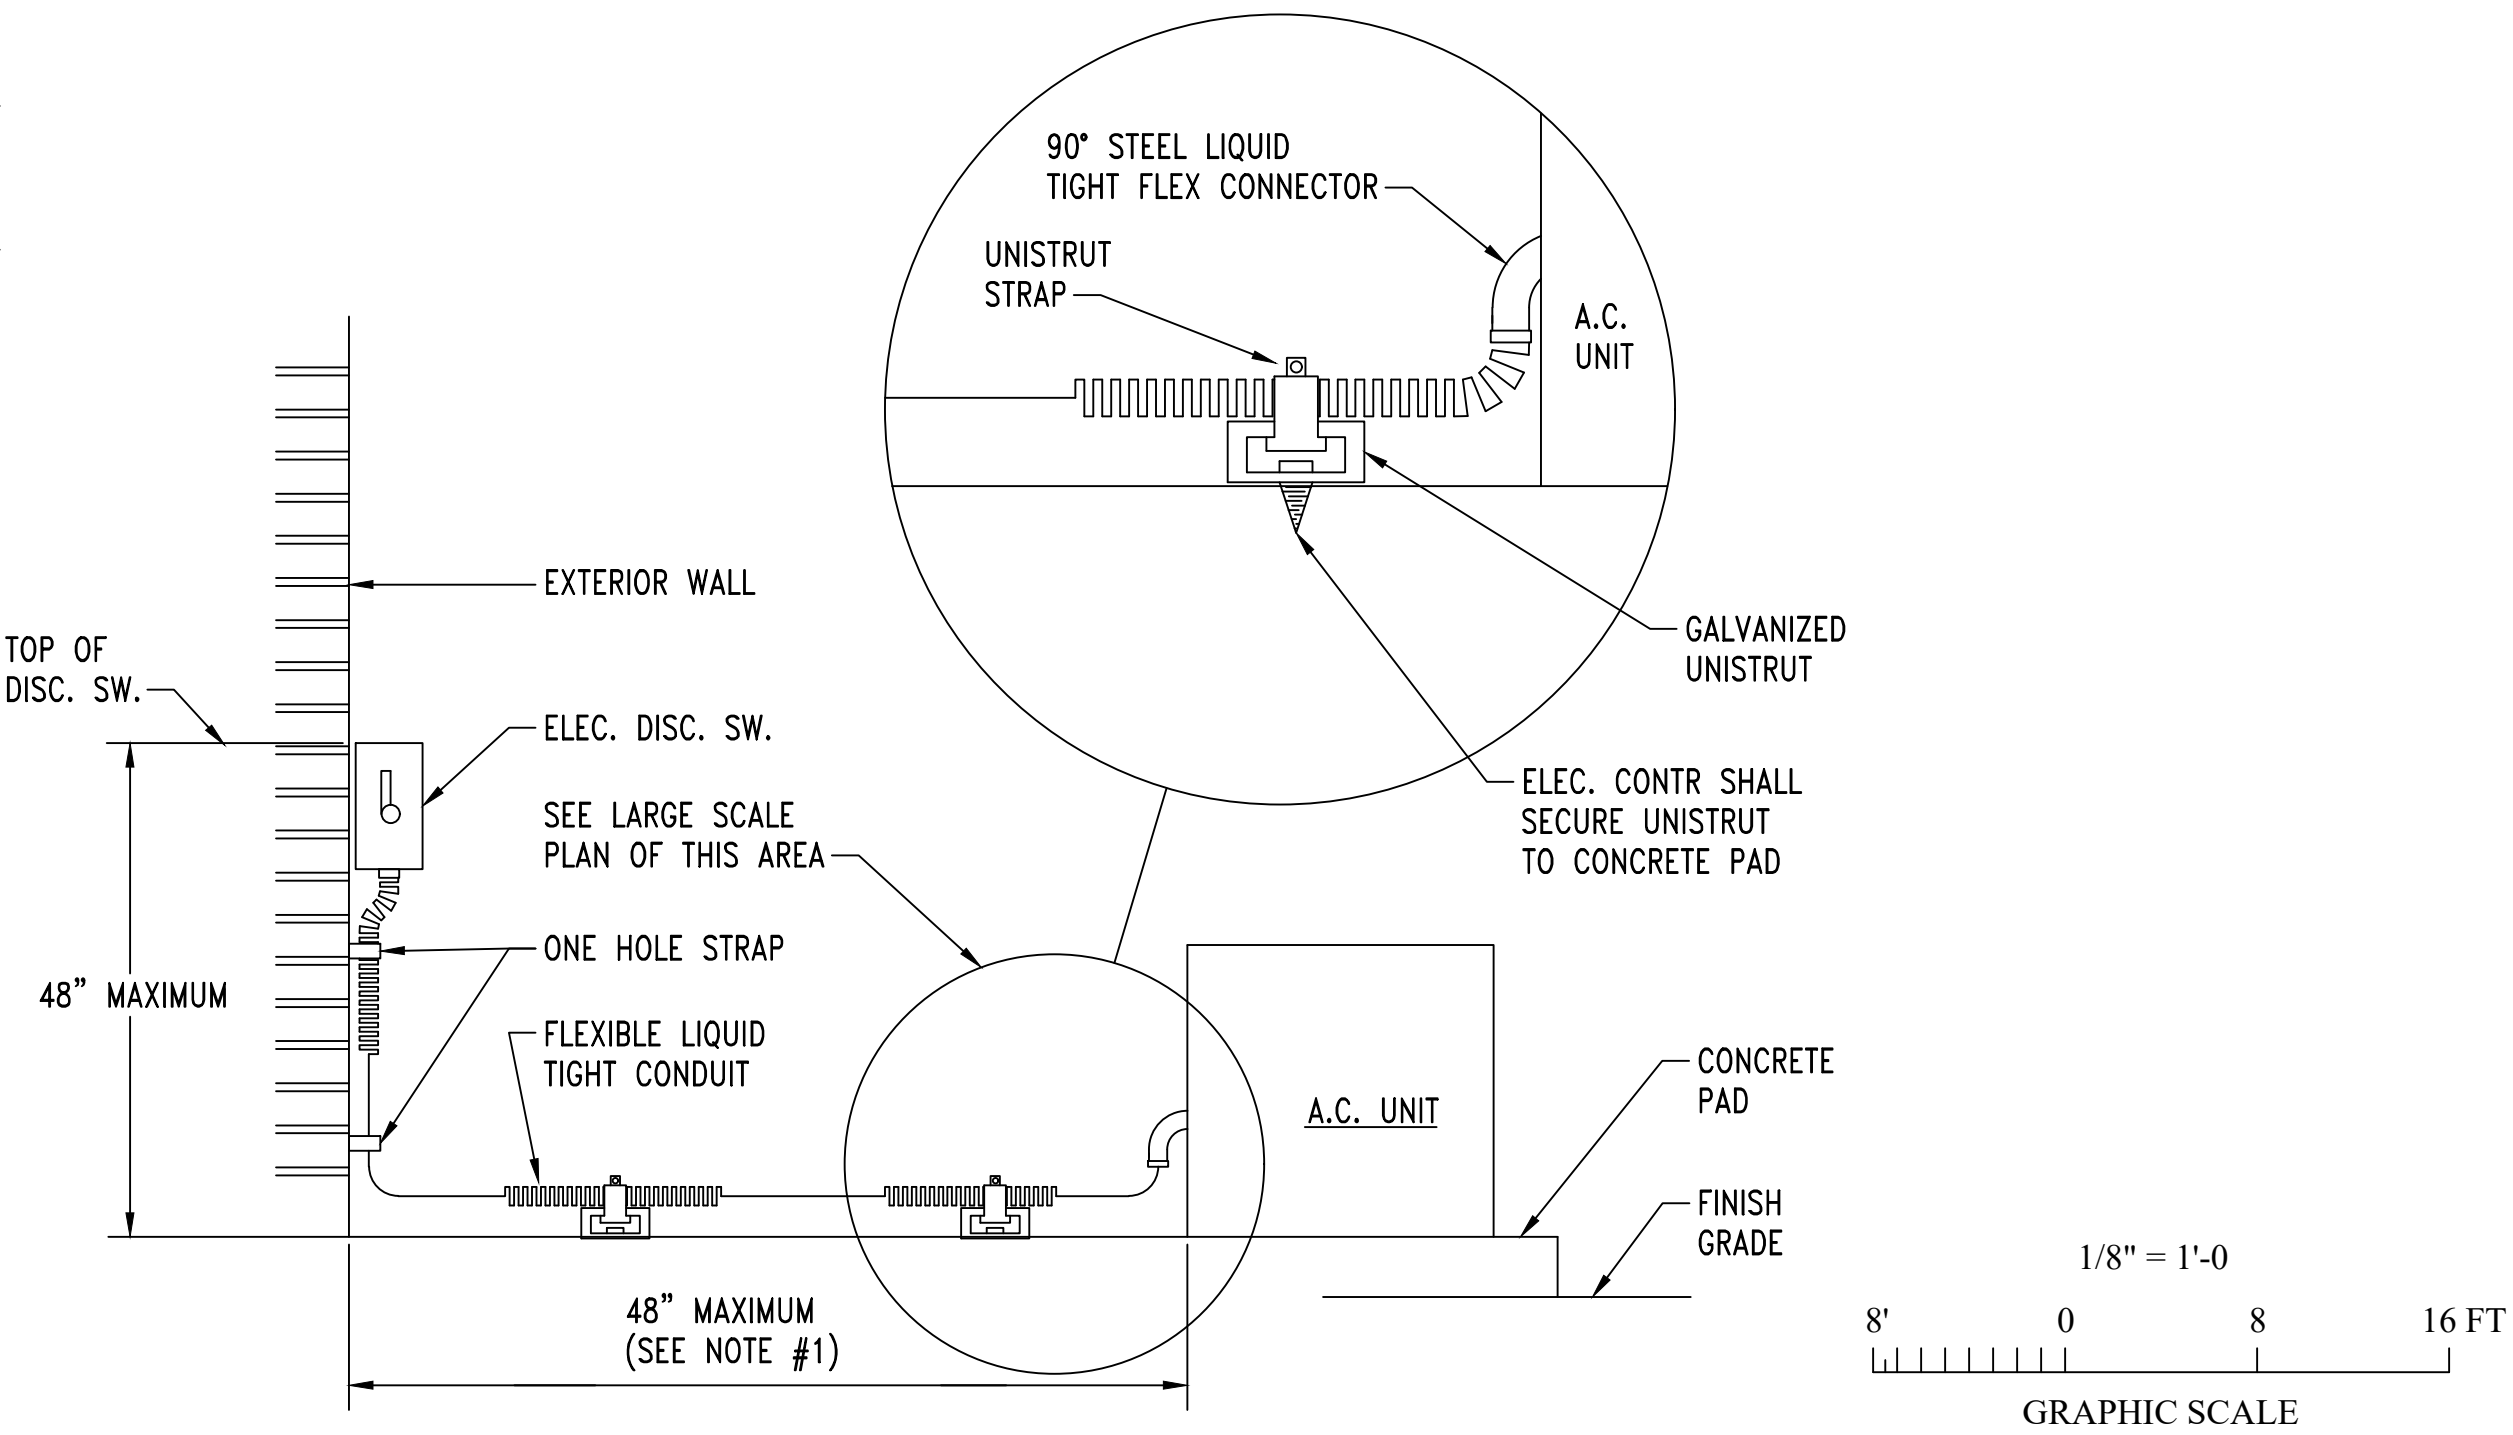

3 MECHANICAL UNIT CONNECTION DETIAL
NO SCALE


GA

Gunn & Associates, P.C.
Consulting Engineers

3102 Highway 14
Millbrook, AL 36054
Tel: 334.285.1273

1200 Providence Park, Suite 200
Birmingham, AL 35242

GA#25-195

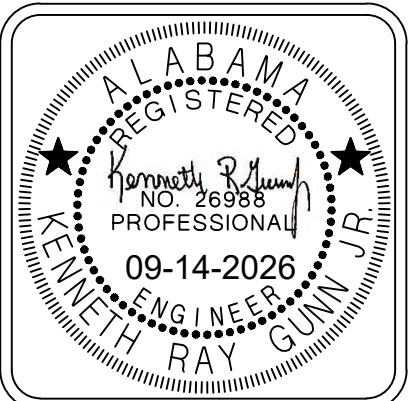

DRAWN	J.C.T.	CHECK	K.R.G.
DATE	8/20/2026	R.T.A.	
REVISED	9-14-2026		
REVISED			
SHEET TITLE FLOOR PLAN - MECHANICAL POWER			
JOB NO. PH&J #2502-CUA DCM #2025417			
SEQUENCE NO. 34 OF 39			

RE-BID
E3.2

ADDENDUM NO.: 1
ATTACHMENT #8

© PH&J ARCHITECTS, INC.
ALL RIGHTS RESERVED

NEW FLEET MANAGEMENT BUILDING

FOR
AIDT
MONTGOMERY, ALABAMA

architects inc.
Montgomery, Alabama




  **FLOOR PLAN - AUXILIARY POWER**
SCALE: 1/8"=1'-0"

architects inc.
Montgomery, Alabama

LIGHTING FIXTURE SCHEDULE						
TYPE:	MANUFACTURER NUMBER AND EQUALS:	VOLTAGE:	MOUNTING:	LAMP TYPE:	LAMP QUANTITY:	DESCRIPTION:
LG22	HUBBELL NO. SRP22-40VLE-EDU OR EQUALS BY WILLIAMS, LUMAX, OR COOPER	MVOLT	RECESSED	LED	4600 LUMEN	2'X2' 4600-LUMEN FLAT PANEL FIXTURE. 0-10V DIMMING CAPABLE.
LG48	HUBBELL NO. SRP24-40ML-EDU OR EQUALS BY WILLIAMS, LUMAX, OR COOPER	MVOLT	RECESSED	LED	5000 LUMEN	2'X4' 5000-LUMEN FLAT PANEL FIXTURE. 0-10V DIMMING CAPABLE.
LG60	HUBBELL NO. SRP24-40HL-EDU OR EQUALS BY WILLIAMS, LUMAX, OR COOPER	MVOLT	RECESSED	LED	6000 LUMEN	2'X4' 6000-LUMEN FLAT PANEL FIXTURE. 0-10V DIMMING CAPABLE.
LG72	HUBBELL NO. SRP24-40VL-EDU OR EQUALS BY WILLIAMS, LUMAX, OR COOPER	MVOLT	RECESSED	LED	7200 LUMEN	2'X4' 7200-LUMEN FLAT PANEL FIXTURE. 0-10V DIMMING CAPABLE.
LS1	HUBBELL NO. LCL-4-4000K-MLE-U OR EQUALS BY WILLIAMS OR COOPER	MVOLT	SURFACE OR CHAIN HUNG	LED	5300 LUMEN	SURFACE MOUNTED 4'-0" LED STRIP. CHAIN HANG WHEN SURFACE MOUNT IS NOT POSSIBLE.
LS86	COLUMBIA NO. MPS8-40DL-CW-EDU OR EQUALS BY WILLIAMS, OR COOPER	MVOLT	SURFACE OR CHAIN HUNG	LED	16924 LUMEN	MULTI-PURPOSE LINEAR, NARROW STRIP LIGHT 8 FEET WITH FROSTED LINEAR PRISMED LENS. 0-10 DIMMING.
LV96	COLUMBIA NO. LXEM8-40VL-RFA-EDU OR EQUALS BY WILLIAMS, OR COOPER	MVOLT	SURFACE OR CHAIN HUNG	LED	6367 LUMEN	LED ENCLOSED & GASKETED, EXTREME ENVIRONMENT 8 FEET LED WITH FROSTED RIBBED ACRYLIC LENS. 0-10 DIMMING.
LW60	HUBBELL NO. ESL-4-40 HL-FA-W U-ELL14H2 OR EQUALS BY LUMAX, WILLIAMS OR COOPER	MVOLT	WALL	LED	6000 LUMEN	4 FOOT WALL MOUNTED LED WALL FIXTURE.
WP1	HUBBELL NO. QSP-30L-4000K-053-TYPE 3-4J-COLOR BY ARCH - SCP-20F OR PRIOR APPROVED EQUALS BY WILLIAMS, OR COOPER	MVOLT	WALL	LED	5700 LUMEN	DARK BRONZE EXTERIOR LED LIGHT. UL LISTED FOR WET LOCATIONS.
EM WALL PACK	COMPASS NO. CU2HLHOSD - WIREGUARDS IN GYM OR PRIOR APPROVED EQUAL BY EMERGH-LITE, MCPHILBEN, OR PRESCOLITE	MVOLT	WALL	LED	1000 LUMEN	1000 LUMEN LED EMERGENCY WALL PACK
EXIT SIGN COMBO "XB"	DUAL-LITE NO. EVCHLU"W12-06L OR PRIOR APPROVED EQUAL BY EMERGH-LITE, MCPHILBEN, OR PRESCOLITE	MVOLT	UNIVERSAL	LED	1000 LUMEN	THERMOPLASTIC 1000-LUMEN COMBO LED EXIT SIGN EGRESS LIGHT. PROVIDE WITH NUMBER OF FACES AND DIRECTIONAL ARROWS AS SHOWN ON DRAWINGS. COORDINATE COLOR OF SIGNAGE WITH LOCAL REQUIREMENTS. PROVIDE WITH EMERGENCY BATTERY. PROVIDE WIREGUARDS IN GYM.
NOTES: 1. ARCHITECT RESERVES THE RIGHT TO SELECT ALL COLORS OR MAKE CUSTOM COLOR DURING SHOP DRAWING REVIEW. BID ACCORDINGLY. 2. COORDINATE MOUNTING OF ALL LUMINAIRES WITH ARCHITECTURAL ELEVATIONS PRIOR TO INSTALLATION. 3. PROVIDE EMERGENCY BATTERY BALLAST FOR ALL EMERGENCY TYPE FIXTURES CAPABLE OF 90-MINUTES. ALL EMERGENCY LIGHTS IN SAFE AREA SHALL BE CONNECTED TO THE BATTERY INVERTER FOR 180-MINUTES OF RUN TIME. 4. FOR WARRANTY AND LONG TERM SUPPORT FOR OWNER, ALL LIGHTING FIXTURES SHALL BE PURCHASED THROUGH MANUFACTURER REPRESENTATIVES LOCATED IN THE STATE OF ALABAMA. SUBMITTALS RECEIVED THAT DO NOT COMPLY WITH THIS REQUIREMENT WILL BE REJECTED WITHOUT REVIEW. THE ELECTRICAL CONTRACTOR SHALL BE RESPONSIBLE FOR ANY DELAYS CAUSED BY NON COMPLIANCE WITH THIS REQUIREMENT. 5. ALL INTERIOR LIGHTS SHALL HAVE 4000K TEMPERATURE LAMPS, UNLESS NOTED OTHERWISE. 6. ALL EXTERIOR LIGHTS SHALL HAVE 4000K TEMPERATURE LAMPS. 7. LIGHTS SPECIFIED WILL BE USED AT BOTH 120V AND 277V CIRCUITS. PROVIDE UNIVERSAL TYPE VOLTAGE DRIVERS FOR ALL LIGHT FIXTURES. IF A SPECIFIC VOLTAGE IS REQUIRED, LIGHTING MANUFACTURER AND CONTRACTOR SHALL WORK TOGETHER TO PROVIDE THE REQUIRED VOLTAGES FOR EACH OF THE DIFFERENT FACILITIES. ENGINEER WILL NOT BE RESPONSIBLE FOR THIS COORDINATION DURING SUBMITTALS. WE WILL ASSUME THE VOLTAGE SUBMITTED IS CORRECT.						

NOTES:

- ALL RECESSED LUMINAIRES SHALL BE WIRED FROM A JUNCTION BOX AS SHOWN, INCLUDING LUMINAIRES IN A CONTINUOUS ROW. NO WIRING THRU FIXTURES. NO MORE THAN TWO LUMINAIRES SHALL BE CIRCUITED TO ONE JUNCTION BOX.
- LUMINAIRE SUPPORT WIRES TO BE A MINIMUM OF #14 GAGE PRE-STRAINED GALVANIZED WIRE ATTACHED AT OPPOSITE CORNERS. LUMINAIRE SHALL BE SUPPORTED TO THE STRUCTURE INDEPENDENT OF THE CEILING GRID.
- CONDUCTORS IN FLEXIBLE CONDUIT FROM JUNCTION BOX TO LUMINAIRE SHALL CONTAIN AN INSULATED GREEN GROUND WIRE, WITH NEUTRAL AND PHASE CONDUCTORS REQUIRED FOR THE CIRCUITING AND SWITCHING REQUIREMENTS INDICATED.
- JUNCTION BOXES SHALL BE ACCESSIBLE AND LOCATED WITHIN 1'-6" ABOVE LAY-IN CEILING INSTALLATION. PROVIDE PENDANT ALL-THREAD RODS AND/OR STRUT ASSEMBLIES TO MEET THIS REQUIREMENT WHERE DROP CEILING IS MORE THAN 1'-6" FROM STRUCTURE.
- CONTRACTOR SHALL INSTALL ALL T-BAR SAFETY CLIPS TO GRID. IF FIXTURE DOES NOT COME WITH GRID SAFETY CLIPS, THEN THE CONTRACTOR SHALL PROVIDE SUPPORT WIRES ON ALL FOUR SIDES.

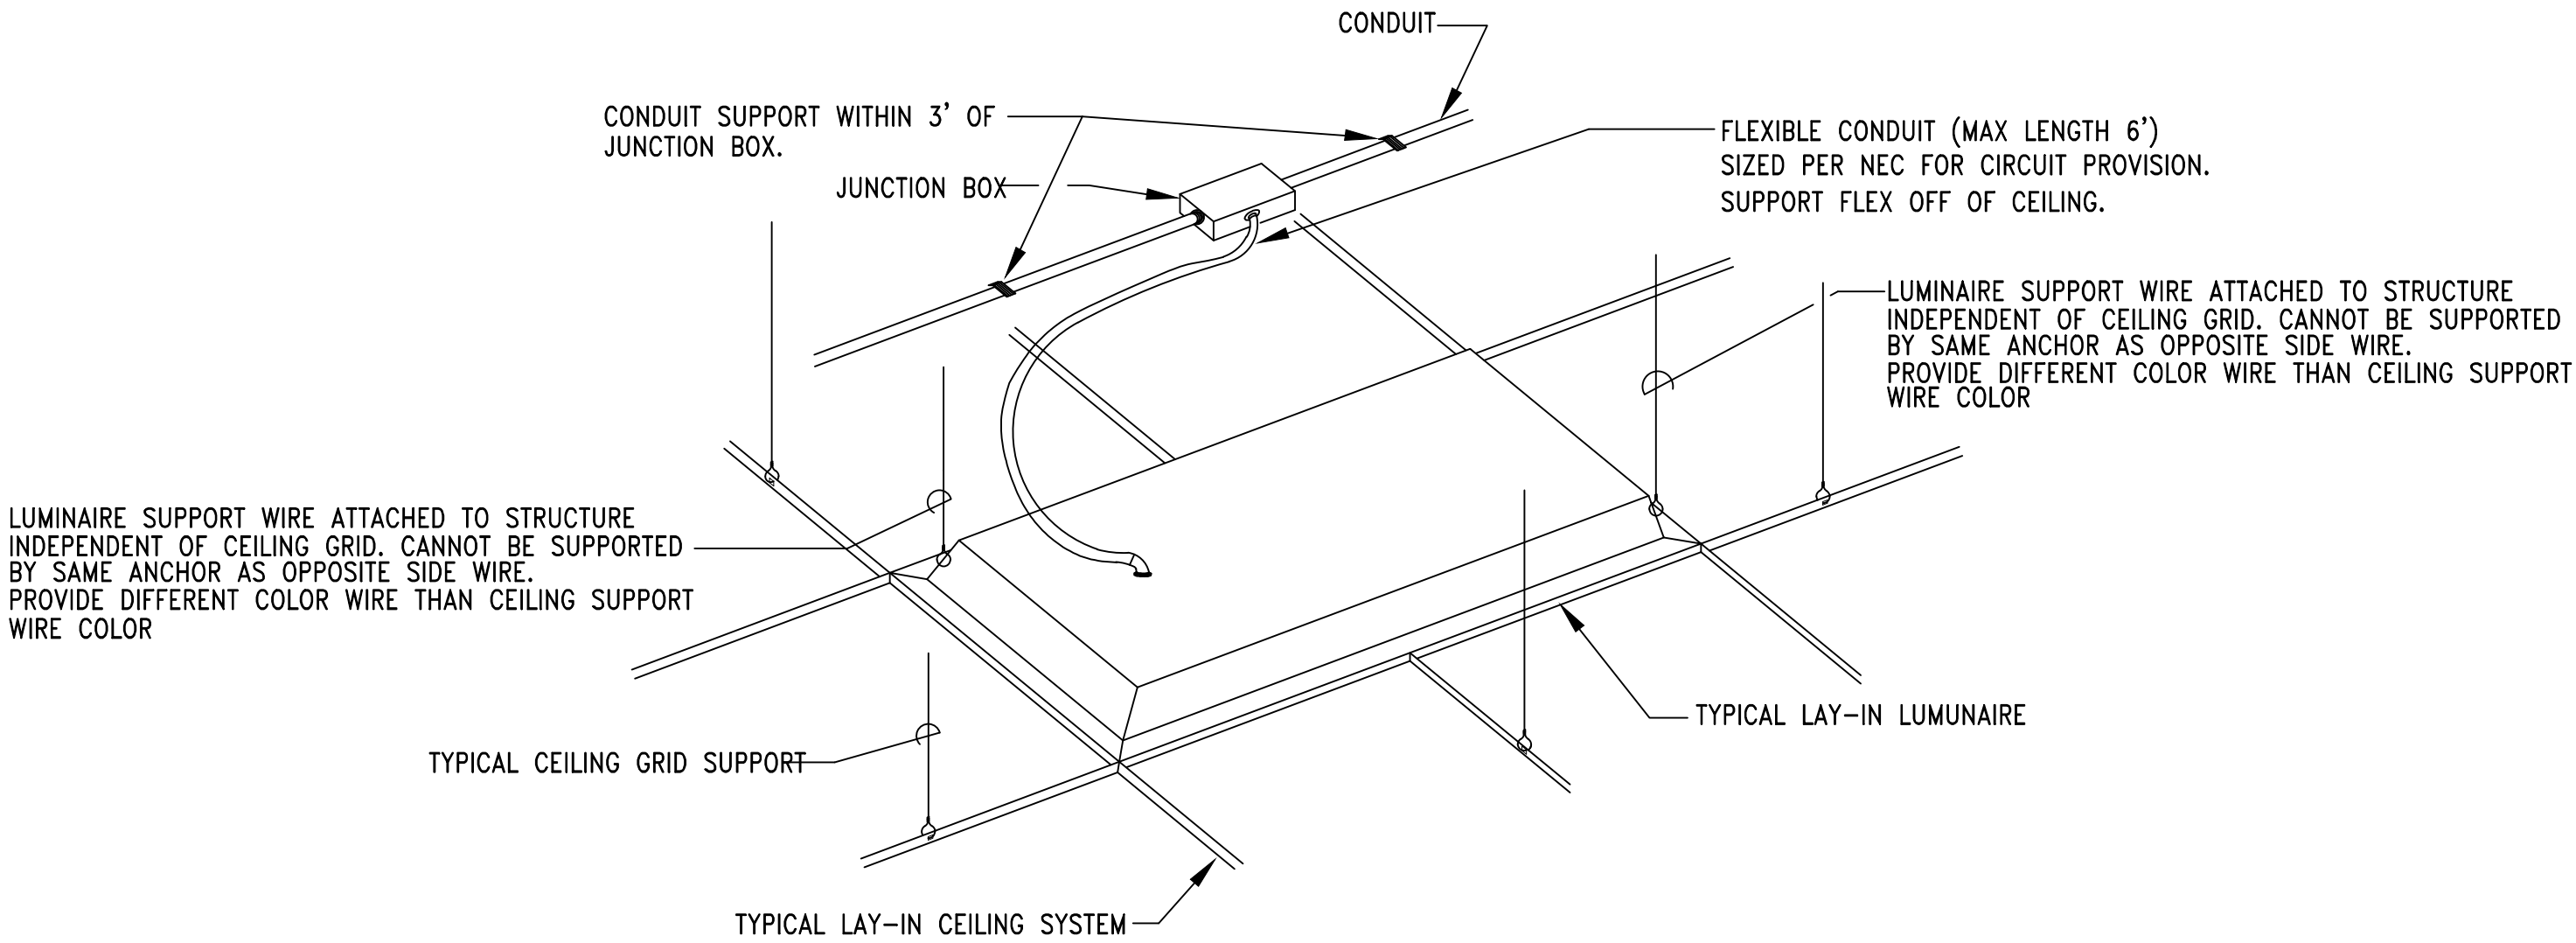


1
ES.1

DETAIL - TYPICAL LAY-IN LUMINAIRE INSTALLATION

NO SCALE

2
ES.1

DETAIL - INSTALLATION OF PHOTO-CELL

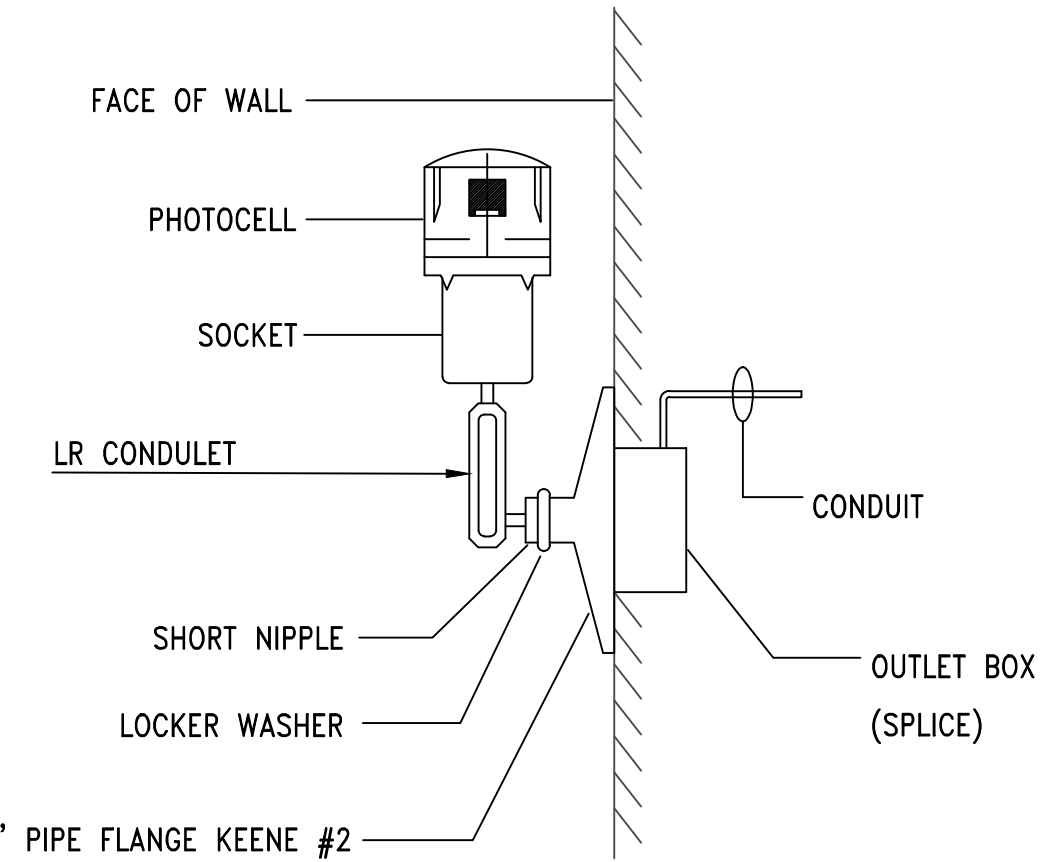

GA

Gunn & Associates, P.C.
Consulting Engineers

3102 Highway 14
Millbrook, AL 36054
Tel: 334.285.1273

1200 Providence Park, Suite 200
Birmingham, AL 35242

GA#25-195

LUMINAIRE NOTES:

- ALL LUMINAIRES AND INSTALLATION SHALL BE IN ACCORDANCE WITH NEC, NFPA AND LOCAL CODES. ALL LUMINAIRES SHALL BE UL LISTED AND INSTALLED IN ACCORDANCE WITH THE UL LISTING.
- LUMINAIRES SHALL BE FURNISHED COMPLETE WITH THE PROPER LAMP BASE OR PIN RECEPTORS, WIRING COMPONENTS, LAMPS, SUPPORTING FRAMES AND DEVICES, ETC., FOR A COMPLETE INSTALLATION.
- ALL LUMINAIRE DEVICES, COMPONENTS, FITTINGS, SUPPORTS, ETC., SHALL BE COORDINATED TO PROVIDE A COMPLETE UL LISTED INSTALLATION
- ALL LUMINAIRES BALLAST, DRIVERS, LAMPS, ETC SHALL BE COMPATIBLE WITH THE LIGHTING CONTROL SYSTEM OR DIMMING CONTROL SYSTEM PROVIDED.
- SECURE EACH LAY-IN LUMINAIRE AT TWO LOCATIONS TO THE CEILING GRID. PROVIDE BOLTS, SCREWS, RIVETS OR APPROVED CLIPS FOR USE WITH THE TYPE CEILING AND LUMINAIRE INSTALLED.
- ALL LUMINAIRES IN MECHANICAL AND ELECTRICAL ROOMS SHALL BE INSTALLED TO CLEAR ELECTRICAL EQUIPMENT, DUCT, PIPING, ETC., SUSPEND BELOW OBSTRUCTION WHEN CONFLICTS OCCUR.
- ALL LED LUMINARIES SHALL BE PROVIDED WITH 4000K COLOR TEMPERATURE LAMPS, UNLESS NOTED OTHERWISE.
- ARCHITECT RESERVES THE RIGHT TO SELECT ALL COLORS FOR LUMINAIRES, POLES, MOUNTING ACCESSORIES, ETC. DURING SHOP DRAWING REVIEW.
- COORDINATE LUMINAIRE MOUNTING WITH ARCHITECTURAL ELEVATIONS PRIOR TO INSTALLATION.
- ALL EXIT SIGNS AND LUMINAIRES DESIGNATED AS EMERGENCY SHALL BE PROVIDED WITH A MINIMUM 1100 LUMEN EMERGENCY BATTERY BALLAST CAPABLE OF 90 MINUTES OF ILLUMINATION. X DESIGNATION MEANS DIFFERENT TYPE BATTERY SEE SCHEDULE.
- CONTRACTOR SHALL PROVIDE ALL SLOPE ADAPTERS, FLANGE KITS, TRIMS, AND ALL OTHER MOUNTING ACCESSORIES AS NEEDED TO MOUNT EACH LUMINAIRE IN CEILINGS AS SHOWN. COORDINATE WITH ARCHITECTURAL REFLECTED CEILING PLANS.
- PROVIDE ALL EXIT SIGNS WITH DIRECTIONAL ARROWS AS SHOWN ON DRAWINGS.

NOTES

- PAINT CONDUIT NIPPLE, SOCKET AND PIPE FLANGE WITH TWO COATS OF ENAMEL.
- COMPLETE ASSEMBLY TO BE UL LISTED FOR WET LOCATIONS.
- PHOTOCELL TO BE MOUNTED FACING NORTH FREE FROM ALL SHADOWS WHICH MIGHT CAUSE PHOTOCELL TO TURN LIGHTS ON EARLY. CONTRACTOR SHALL COORDINATE PROPER MOUNTING LOCATION PRIOR TO INSTALLATION.

NEW FLEET MANAGEMENT BUILDING

FOR
AIDT
MONTGOMERY, ALABAMA

DRAWN	J.C.T.	CHECK	K.R.G.
DATE	8/20/2026	R.T.A.	
REVISED	9-14-2026		
REVISED			

SHEET TITLE
LIGHTING SCHEDULE,
DETAILS & NOTES

JOB NO. PH&J #2502-CUA
DCM #2025417

SEQUENCE NO. 36 OF 39

RE-BID
E5.1


ADDENDUM NO.: 1
ATTACHMENT #10
© PH&J ARCHITECTS, INC.
ALL RIGHTS RESERVED

architects inc.
Montgomery, Alabama

RE-BID AIDT FLEET MANAGEMENT 2502-CUA

DETAIL KEYED NOTES

- 1 FLOOR ANCHOR SYSTEM
2 VIBRATION ISOLATORS – TYP. FOR FOUR
3 FLEXIBLE CONNECTION
4 GROUND BUSSING TERMINATIONS
5 NAMEPLATE
6 TRANSFORMER IDENTIFICATION PLATE
7 VENTED COVER
8 4" HIGH CONCRETE HOUSE-KEEPING PAD WITH 45° 1" CHAMFER

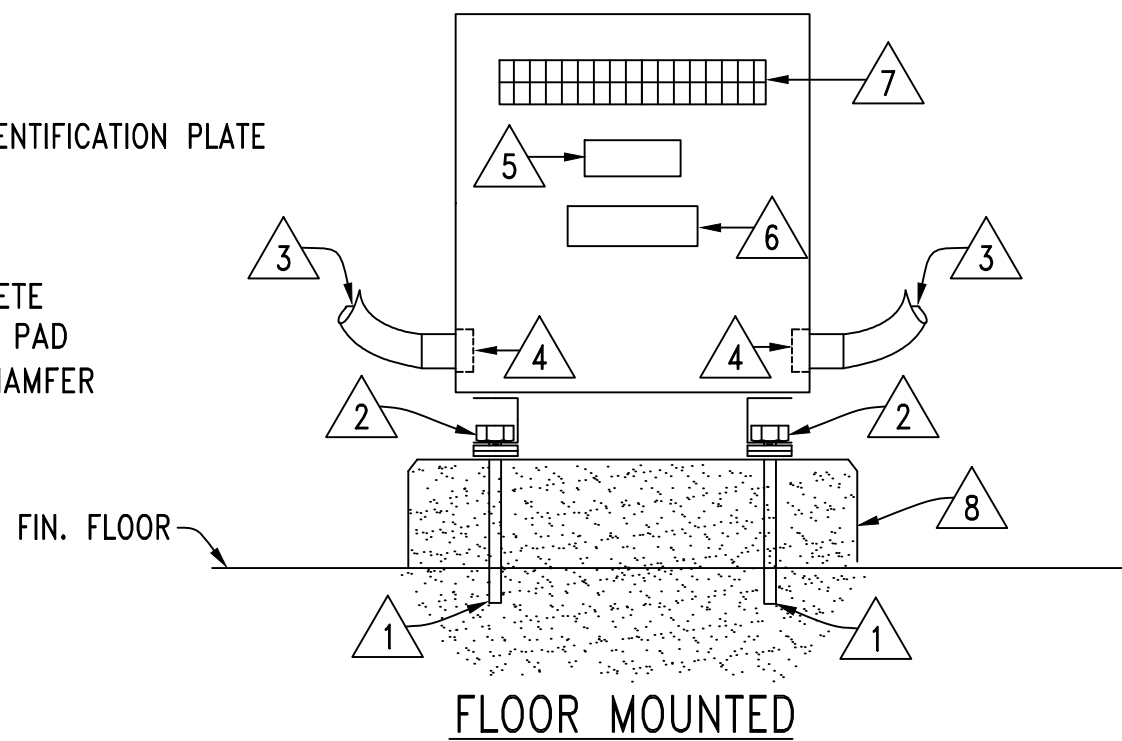

INSTALLATION NOTES:


1. SIZE ALL SUPPORTS, ANCHOR SYSTEMS, BOLTS, ETC., AS REQUIRED FOR A SECURE INSTALLATION IN ACCORDANCE WITH THE SPECIFICATIONS.

DRY TYPE TRANSFORMER SCHEDULE

MARK	KVA	VOLTAGE		°C RISE	K FACTOR	NOTES
		PRIMARY	SECONDARY			
TX-1	75	480 V. DELTA 3 PH., 3 W.	208Y/120 V. 3 PH., 4 W.	150	1	1

NOTES:

1. CONTRACTOR SHALL CALCULATE AND PROVIDE NAMEPLATE ON THE SERVICE ENTRANCE EQUIPMENT THAT INDICATES THE MAXIMUM AVAILABLE FAULT CURRENT AND THE DATE THE CALCUALTION WAS PERFORMED. SEE NAMEPLATE REQUIREMENTS BELOW.

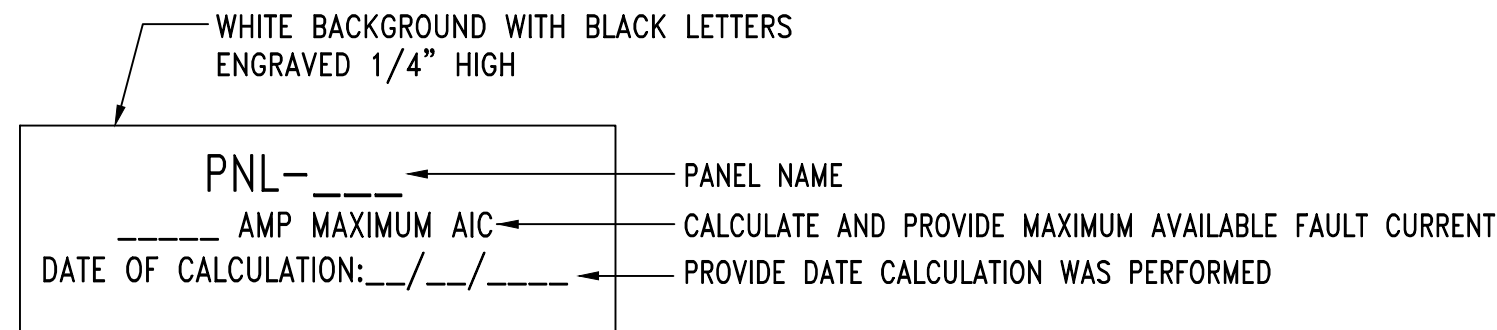


TYPICAL SERVICE ENTRANCE FAULT CURRENT NAMEPLATE

DETAIL-TYPICAL INDOOR INSTALLATION OF DRY TYPE TRANSFORMERS

POWER RISER DIAGRAM NOTES:

1. INSTALLATION AND CONNECTION OF ALL DEVICES SHALL BE IN ACCORDANCE WITH NEC, MANUFACTURER'S RECOMMENDATIONS, AND STATE AND LOCAL CODES.
2. CONTRACTOR IS RESPONSIBLE FOR THE CONNECTING, INSTALLATION, AND MARKING OF ALL POWER FEEDER CONDUCTORS FOR THE PROPER PHASE SEQUENCE AND LOADING. CONTRACTOR SHALL TEST EACH FEEDER AND EQUIPMENT FEEDERS WITH A PHASE METER PRIOR TO CONNECTING LOADS.
3. THE CONTRACTOR IS RESPONSIBLE FOR COORDINATING AND VERIFYING WITH ALL DIVISIONS THE ACTUAL NAMEPLATE DATA OF ALL EQUIPMENT AND DEVICES SUPPLIED ON THIS PROJECT PRIOR TO BID. CONTRACTOR SHALL THEN PROVIDE THE PROPERLY SIZED OVERCURRENT DEVICES (CIRCUIT BREAKERS, CONDUCTORS, DISCONNECTS, FUSES, ETC.) TO PROPERLY PROTECT THE EQUIPMENT PER THE NEC. ENGINEER'S DESIGN BASED ON DATA GIVEN TO HIM BY DESIGNERS OF OTHER DIVISIONS, ACTUAL NAMEPLATE DATA COULD DIFFER.
4. SEAL ALL CONDUITS FROM THE EXTERIOR WITH A SEALING COMPOUND, ONCE ALL CABLING HAS BEEN INSTALLED.
5. PROVIDE 4" CONCRETE HOUSEKEEPING PAD WITH 1" CHAMFER FOR ALL FLOOR MOUNTED TRANSFORMERS AND SWITCHBOARDS.
6. COORDINATE WITH GROUNDING DETAILS ON SHEET E7.2 FOR ALL THE DIFFERENT TYPE GROUNDING REQUIREMENTS.
7. ALL UNDERGROUND SECONDARY FEEDERS SHALL BE A MINIMUM OF 36" BELOW GRADE TO THE TOP OF THE DUCT BANK.
8. ALL UNDERGROUND PRIMARY FEEDERS SHALL BE A MINIMUM OF 48" BELOW GRADE TO THE TOP OF THE CONDUIT.
9. CONTRACTOR SHALL PROVIDE A FULL SIZE COPY OF THE AS-BUILT POWER RISER DIAGRAM FRAMED BEHIND PLEXIGLASS SCREWED TO THE WALL NEAR MAIN SERVICE PANEL.

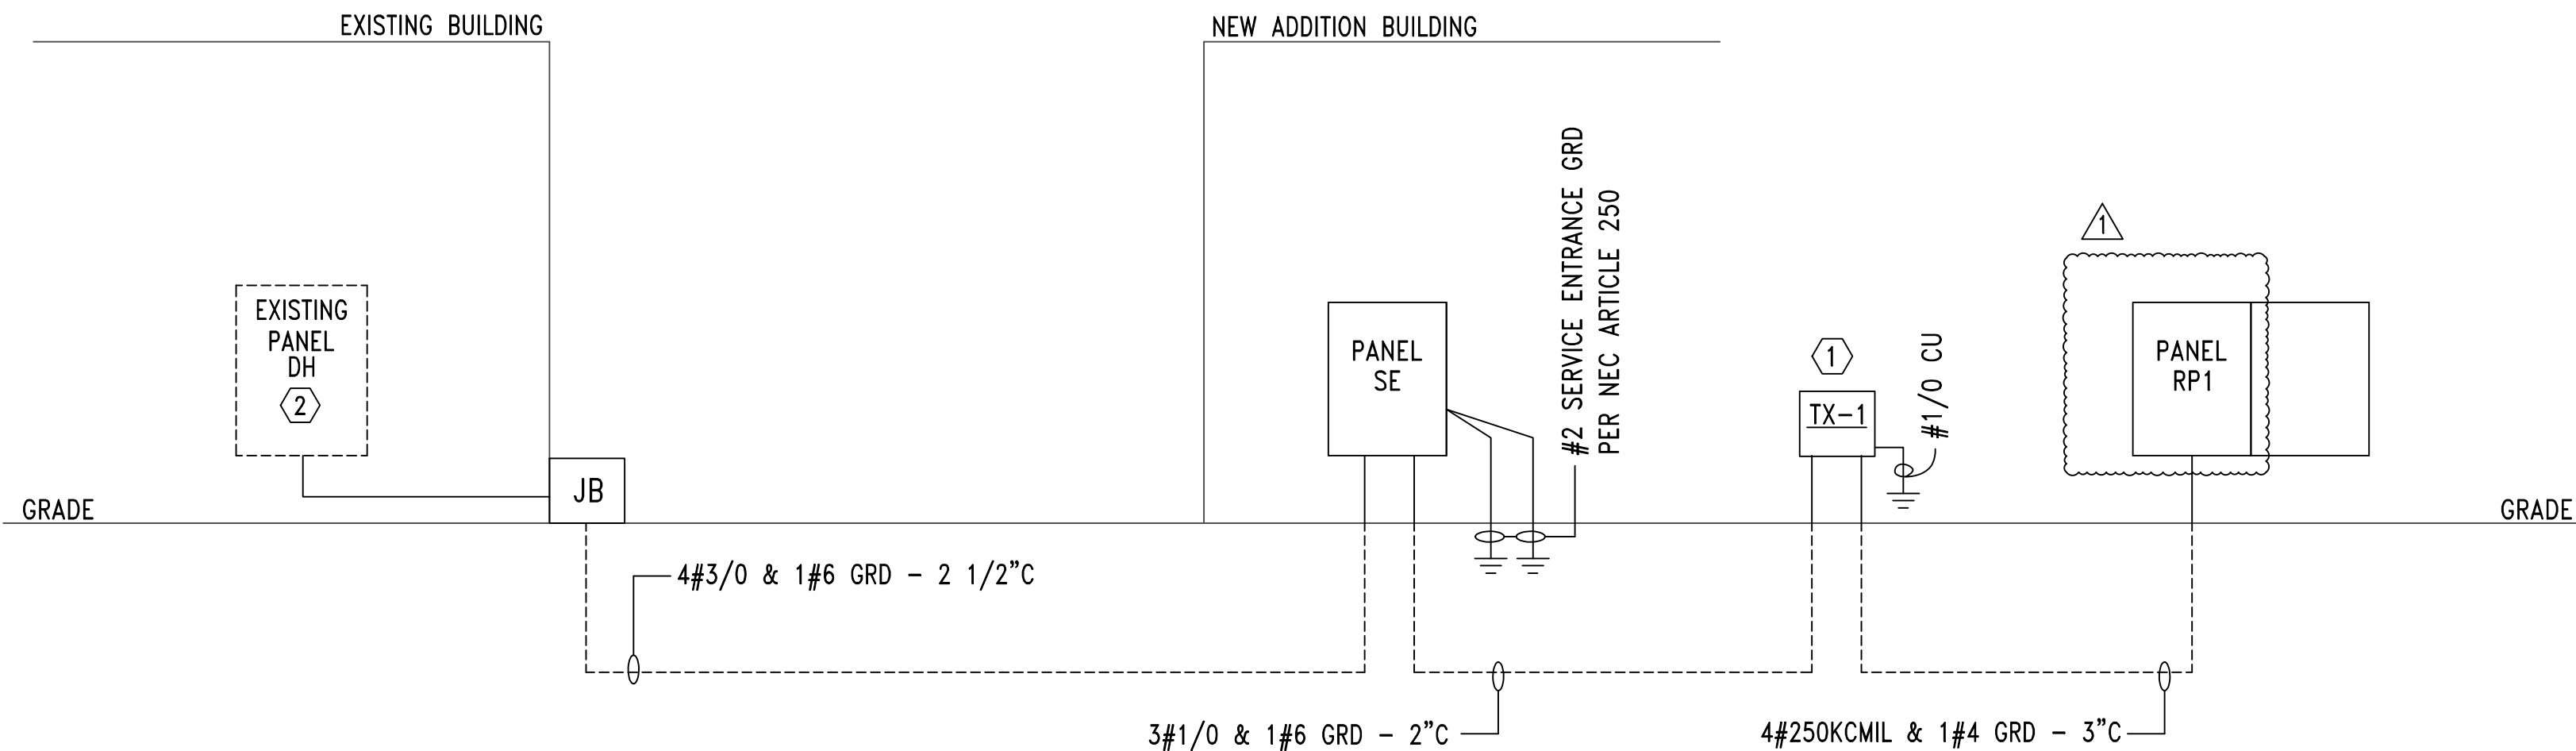

POWER RISER DIAGRAM

DETAIL - SERVICE ENTRANCE FAULT CURRENT NAMEPLATE

SHEET NOTES:

- 1 SEE DETAIL 2/E7.1 FOR TRANSFORMER INSTALLATION REQUIREMENTS.
2 PROVIDE NEW 200A/3P (65K AIC) CIRCUIT BREAKER TO FEED NEW PANEL SE.



DRAWN	J.C.T.	CHECK	K.R.G.
DATE	8/20/2026 R.T.A.		
REVISED	9-14-2026		
REVISED			

SHEET TITLE
POWER RISER DIAGRAM,
DETAILS & NOTES

JOB NO. PH&J #2502-CUA
DCM #2025417

SEQUENCE
NO. 39 OF 39

RE-BID
E7.1

! { { "bu (b a huZ...
! qop ! k e a "hup , 11

© PH&J ARCHITECTS, INC.
ALL RIGHTS RESERVED

Gunn & Associates, P.C.
Consulting Engineers
3102 Highway 14
Millbrook, AL 36054
Tel: 334.285.1273
1200 Providence Park, Suite 200
Birmingham, AL 35242
GA#25-195

NEW FLEET MANAGEMENT BUILDING

FOR
AIDT

MONTGOMERY, ALABAMA

architects inc.
Montgomery,
Alabama